

APPENDIX I


Building Fire Protection Plan

St. Francis College leases 179 Livingston Street, Brooklyn, New York Floors 5, 6 and 7 and has collaborated with the building responsible on the site Fire Protection Plan approved by the New York Fire Department. Following is the approved plan prepared by Perkins-Eastman for this site including evacuation routes and plan, floor plans with identified safety equipment and exits, and building fire and life safety systems:

The following

- Individual Floor Fire Alarm Staging Areas and Evacuation Diagrams
- Fire Protection Plan Narrative (1-16)
- Building Card Floor Diagrams with Evacuation Routes and Floor Plans (1-27)
- Building Diagrams (1-3)

- CHAPEL
- THE CONSERVATORY
- DINING HALL
- EDUCATION INNOVATION FACTORY
- FACULTY SUITE
- FITNESS ROOM AND LOCKER ROOMS
- FRANCIS HALL
- GRADUATE AND UNDERGRADUATE AFFAIRS
- INTERFAITH PRAYER ROOM
- IT SERVICE DESK
- MINISTRY SUITE
- MULTIMEDIA LEARNING HUB
- OIEA (INSTITUTIONAL RESEARCH)
- THE QUAD
- SPECIAL EVENTS
- STUDENT ADMISSIONS AND STUDENT FINANCES
- STUDENT UNION AND GOVERNANCE
- TERRACE
- DIGITAL CONTENT PRODUCTION LAB
- WELCOME DESK

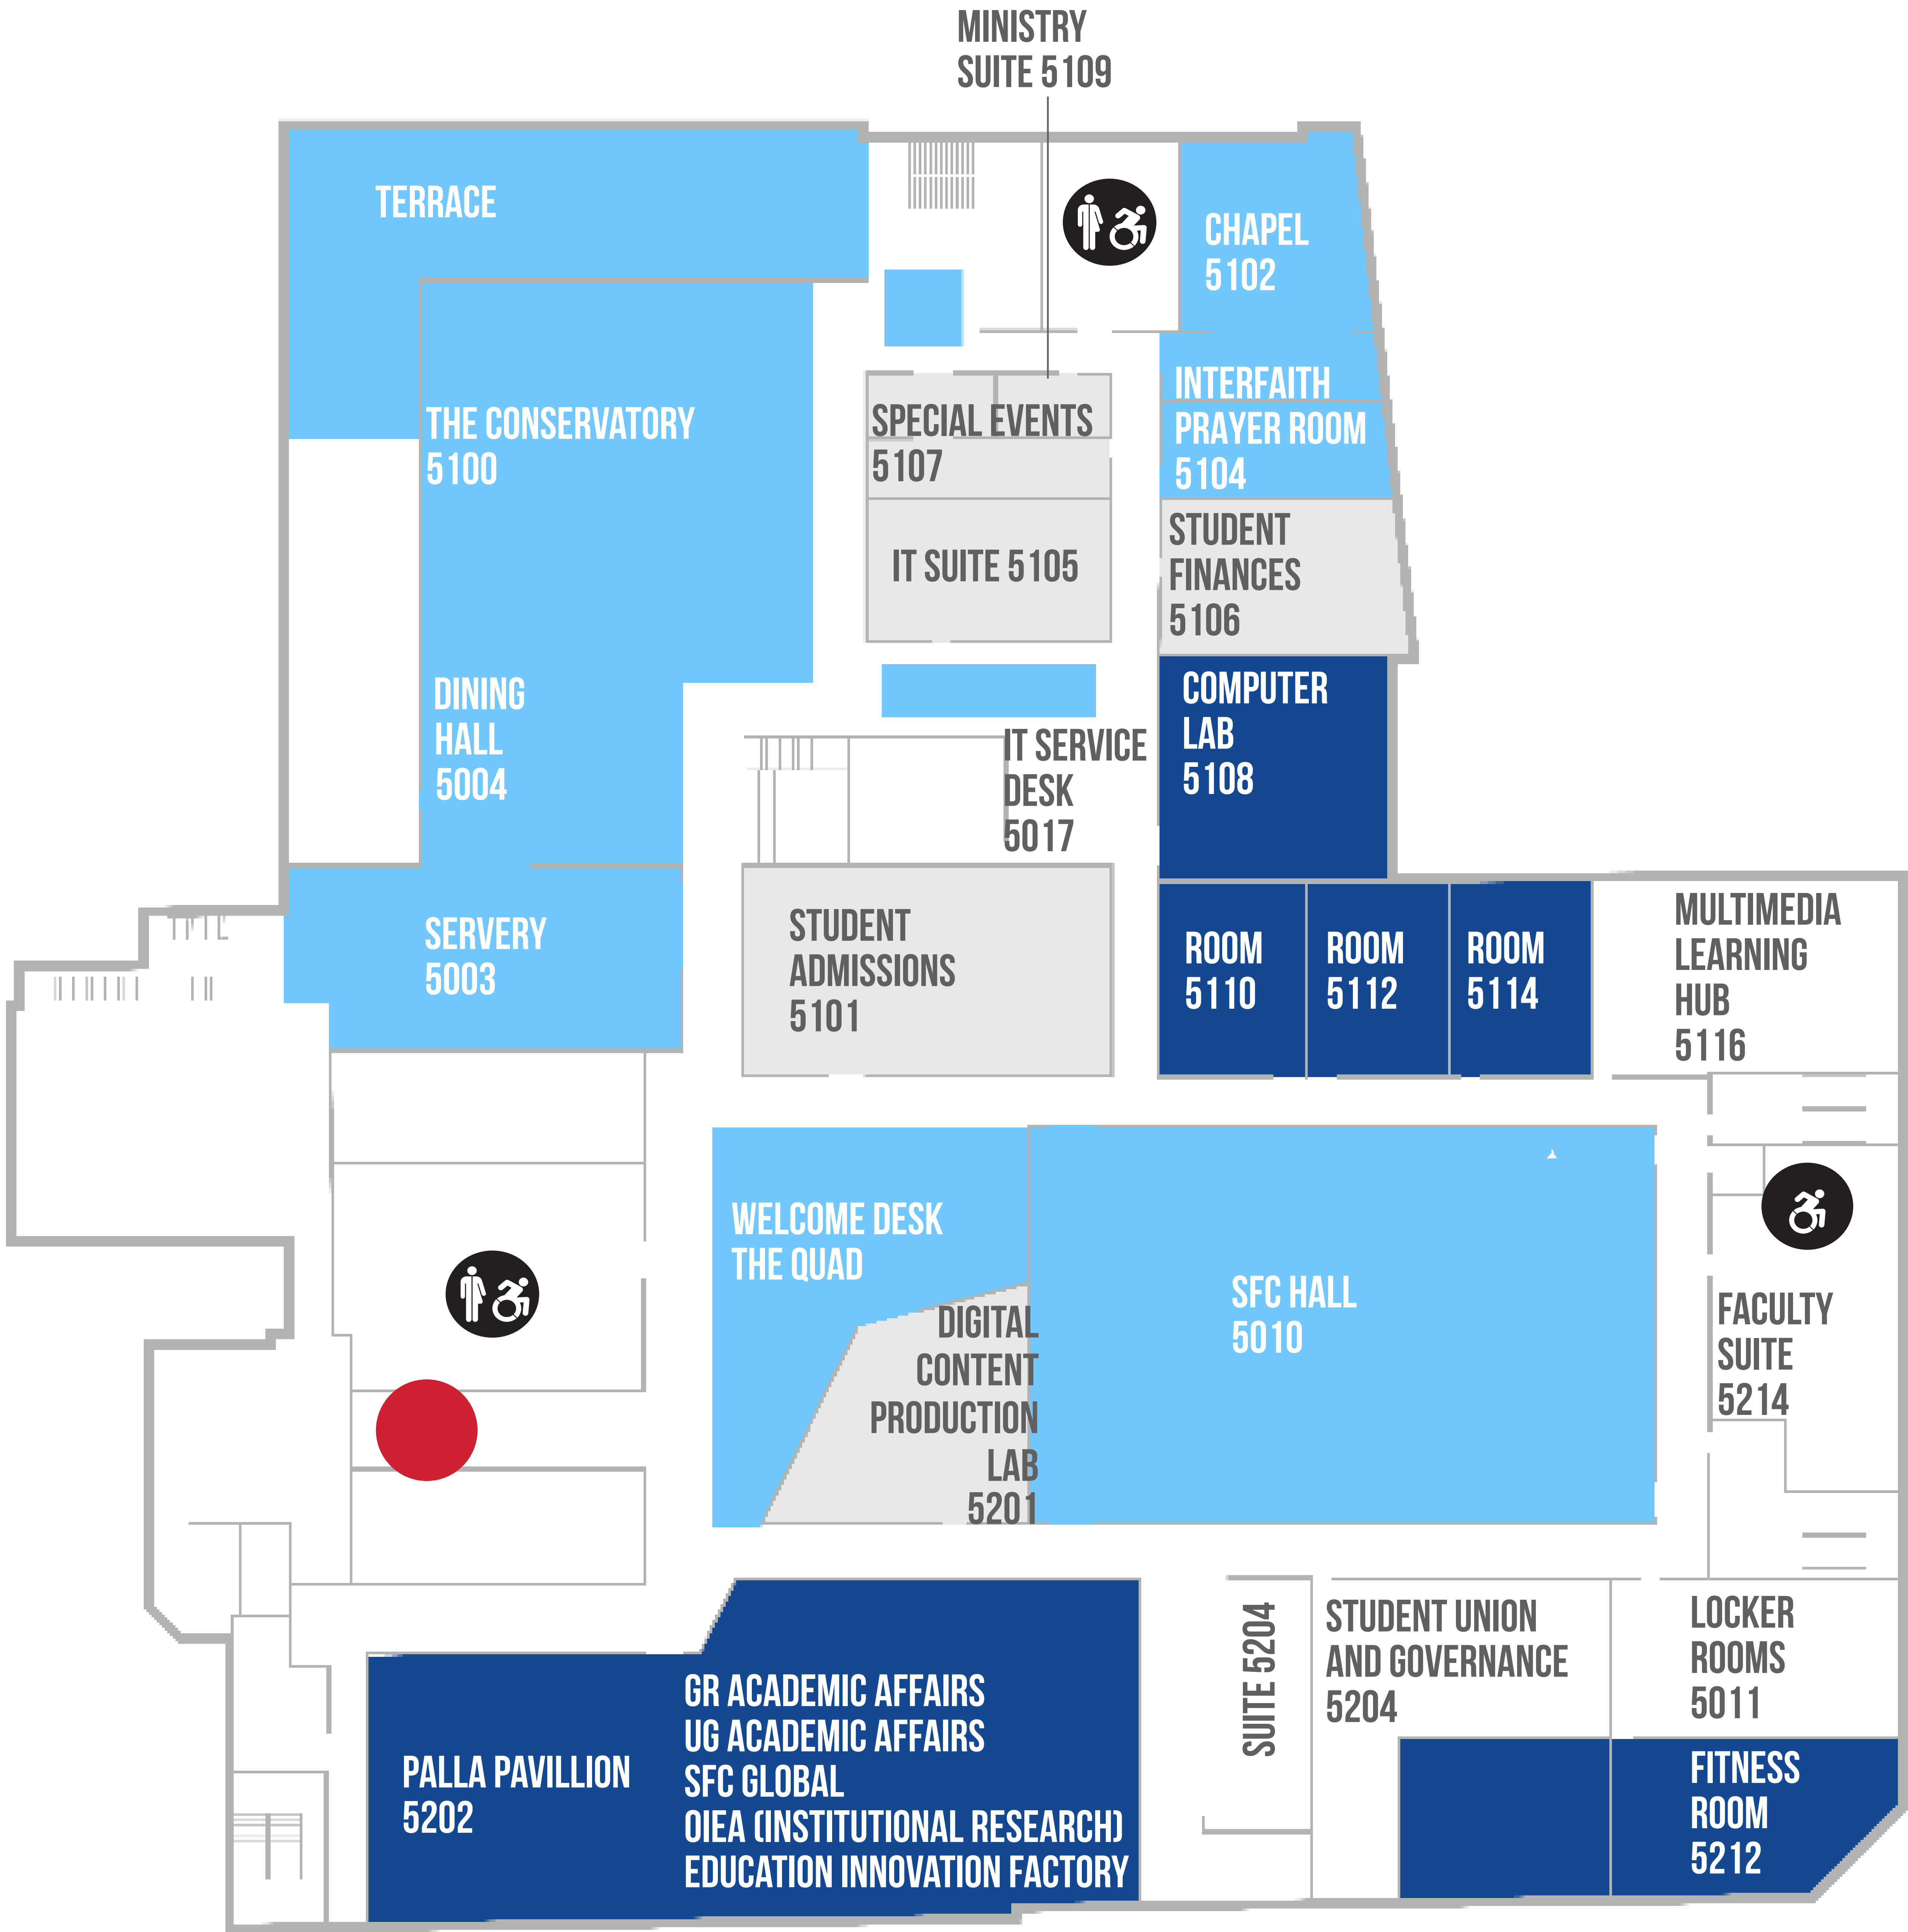

- Elevator
- Restrooms
- Stairs
- Student Support Centers and Services
- Student Collaboration, Study, and Social Spaces
- Classrooms, Labs, and Academic Spaces

ADJUNCT FACULTY LOUNGE

CLL AND OPPORTUNITY PROGRAMS

E-SPORTS

FACILITIES

FACULTY SUITES

FINANCIAL AFFAIRS

HONORS CLASSROOM

HUMAN RESOURCES

MAILROOM/COPY CENTER

RECHARGE ROOM

SFC RADIO

STUDENT AFFAIRS LEADERSHIP



- Elevator
- Restrooms
- Stairs
- Student Support Centers and Services
- Student Collaboration, Study, and Social Spaces
- Classrooms, Labs, and Academic Spaces

EXECUTIVE SUITE

FACULTY SUITES


HEALTH AND WELLNESS CENTER

LACTATION ROOM

REGISTRAR

THE PLAZA

VOLPE CENTER OF ACCOMMODATIONS AND
SUCCESES

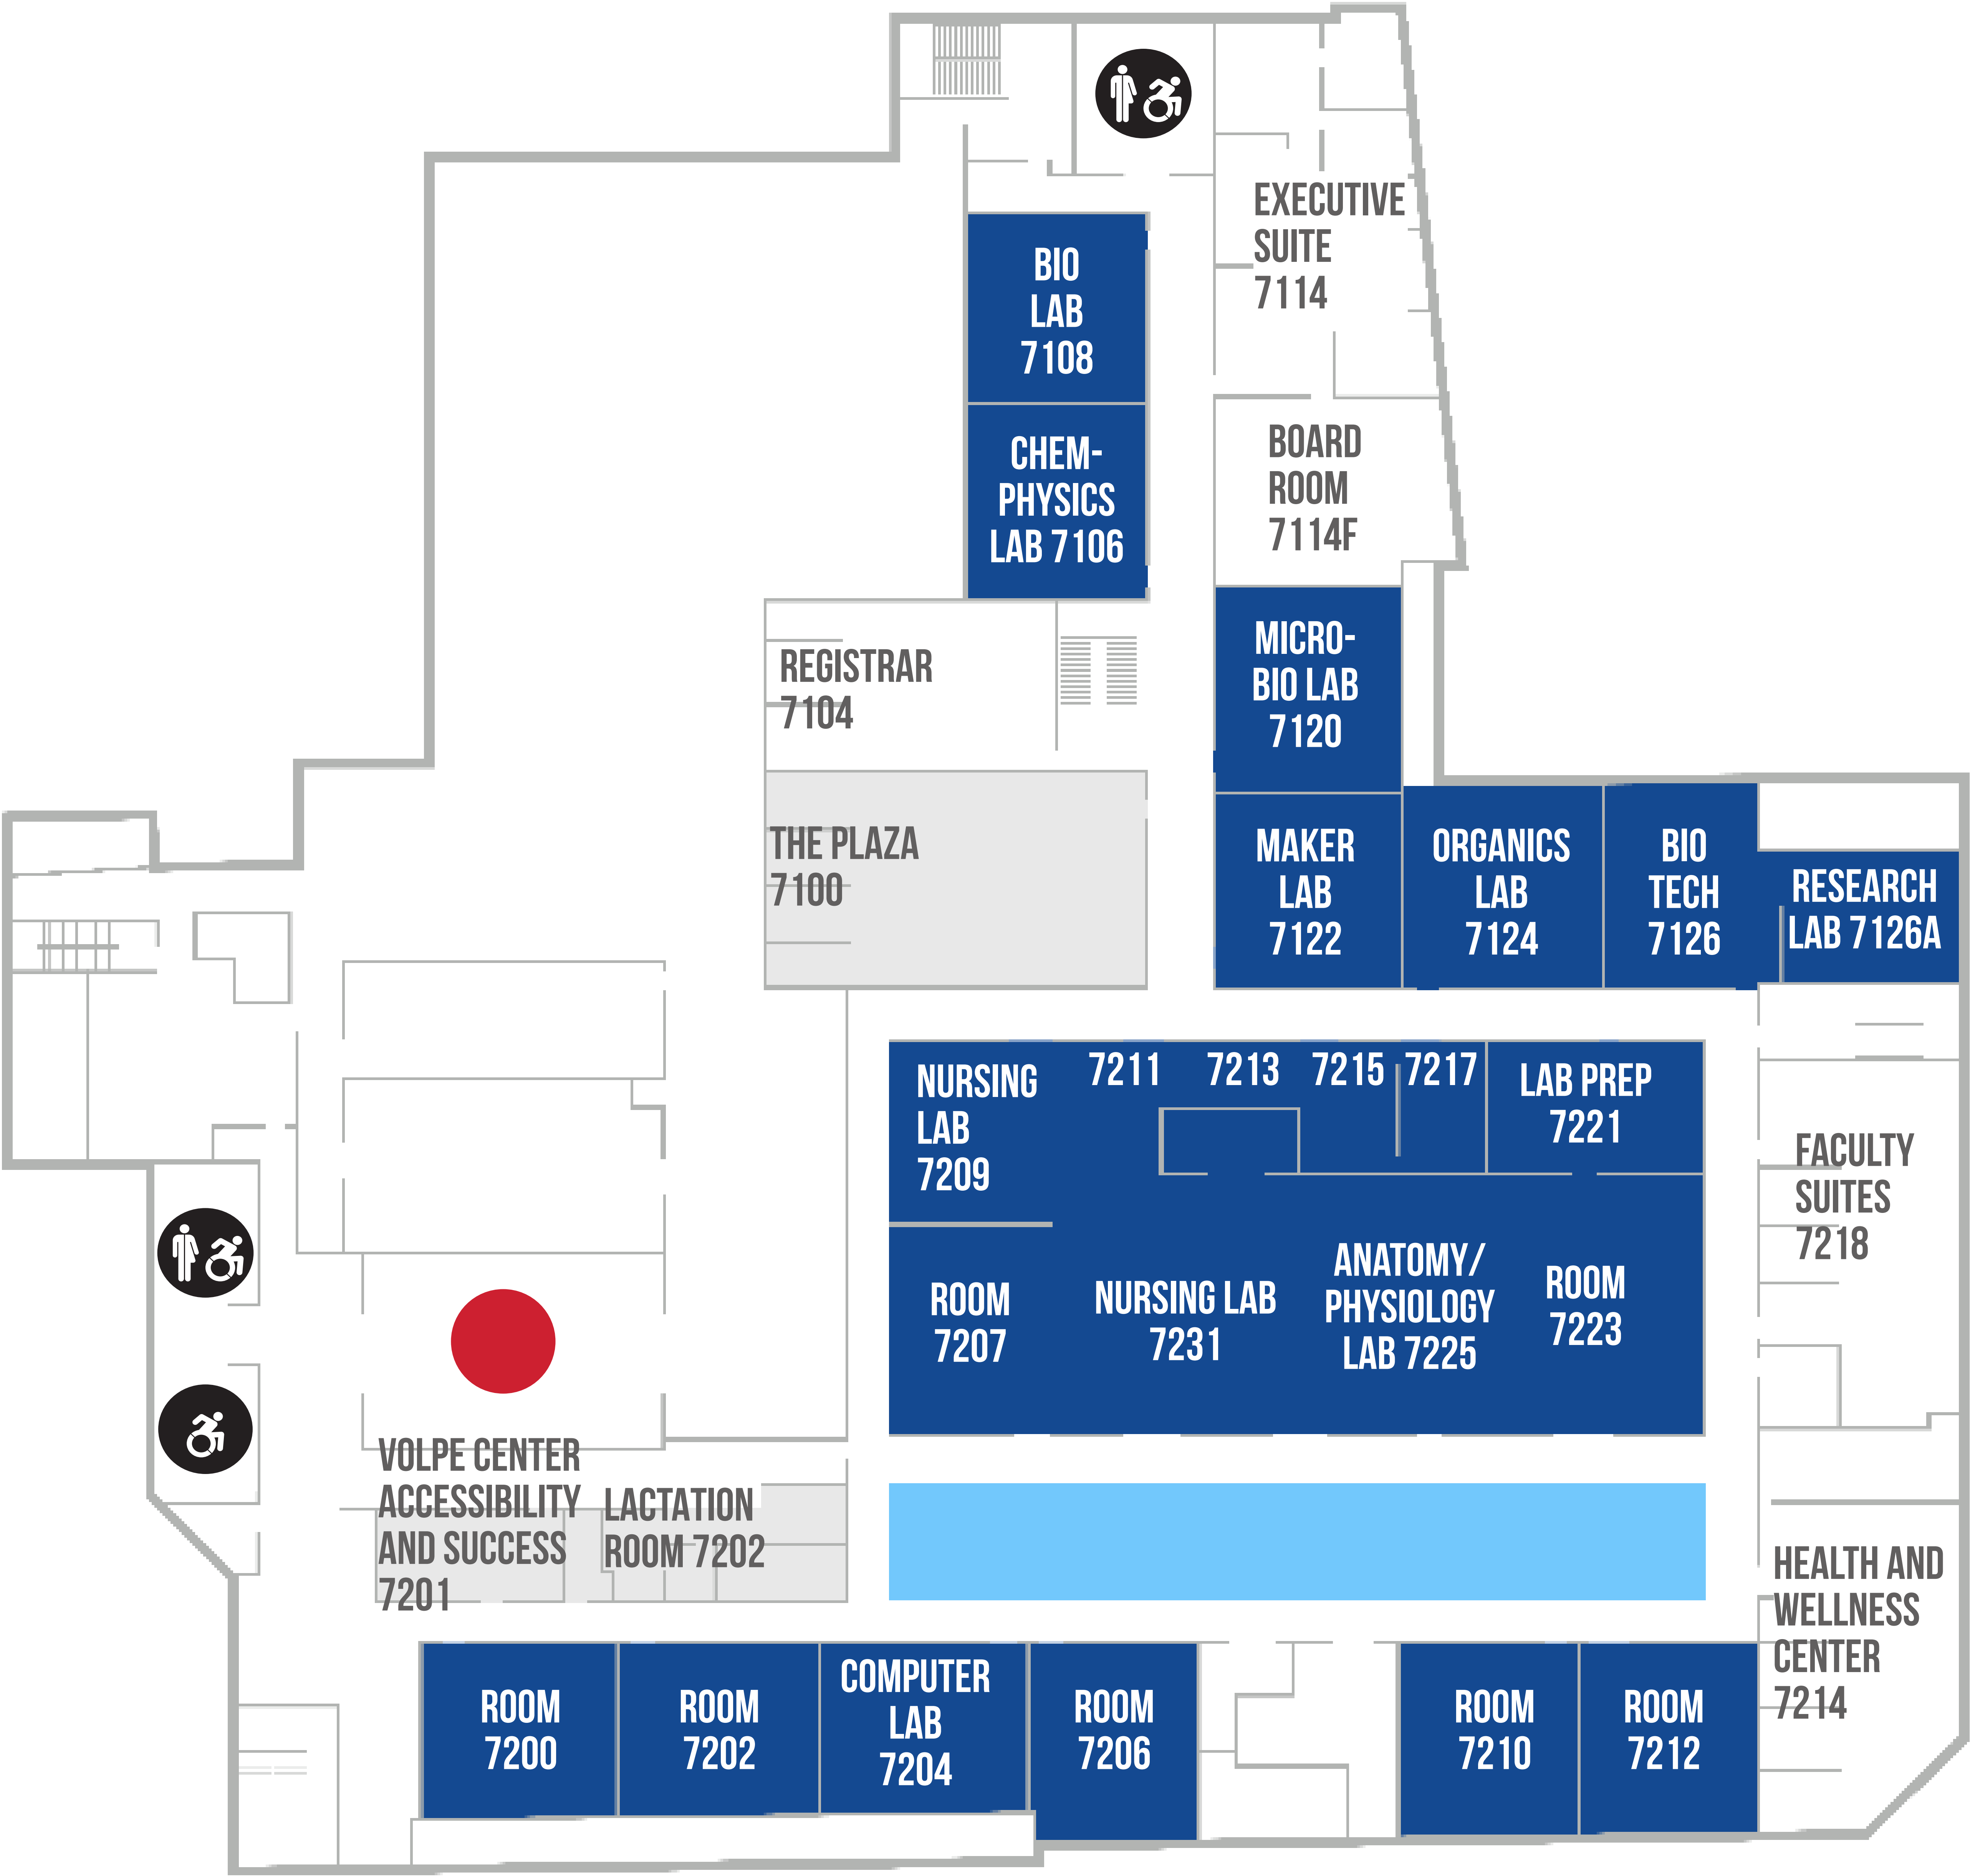

- Elevator
- Restrooms
- Stairs
- Student Support Centers and Services
- Student Collaboration, Study, and Social Spaces
- Classrooms, Labs, and Academic Spaces

Fire Protection Plan Narrative

422 Fulton Street, Brooklyn, NY 11201

Date: July 27, 2022

**PERKINS —
EASTMAN****Fire Protective Plan Narrative**422 Fulton Street
Brooklyn, NY 11201**Owner**Business Use:422 Fulton Owner, L.L.C.
45 Rockefeller Plaza
New York, NY 10111Mercantile Use:422 Fulton Condominium
Macy's Retail Holdings, Inc.
7 West Seventh Street
Cincinnati, OH 45202**Architect:**Business Use (Core and Shell)Perkins Eastman
115 Fifth Avenue
New York, NY 10003Mercantile Use:Highland Associates
One East 33rd Street
New York, NY 10016**MEPFP Engineer:**Business Use (Core and Shell)Cosentini
498 Seventh Avenue
New York, NY 10018Mercantile Use:Highland Associates
One East 33rd Street
New York, NY 10016**Expeditor for Fire Protection Plan:**Jerome S Gillman Consulting
40 Worth Street, Room 600
New York, NY 10013

1. Project Introduction

1.1 Existing Building Renovation / Addition and Change of Use

The project is partial gut renovation and vertical enlargement of an existing building at 422 Fulton Street.

Existing Building:

Existing building is a Macy's Department Store, with Mercantile occupancy.

Existing building size:

- Approximate height: 208'-3" to highest roof
- Floors above grade: (9), plus (3) Penthouse levels and (1) Mezzanine
- Floors below grade: (3) plus (1) Mezzanine

Building after renovation and enlargement:

Macy's (Mercantile use) will remain in the building, occupying Sub-Cellar 2 through 4th Floor, with exceptions as noted. Macy's will maintain the 422 Fulton Street address. **This portion will be referred to as "Mercantile Use" in this narrative.**

Business use for Offices and Higher Education is a new occupancy type in the building, occupying 5th Floor to 14/F and Penthouse 1 to 3. It partially occupies 1/F, Cellar Mezzanine and Sub-Cellar 1. Two street level entrances leading to new dedicated lobbies and building core will be at 179 (Business - Higher Education) and 181 Livingston Street (Business - Office). The two lobbies are connected by doors. **This portion will be referred to as "Business Use" in this narrative.**

New building size:

- Approximate height: 276'-6" to highest roof
- Floors above grade: (15), plus (2) Penthouse levels and (1) Mezzanine
- Floors below grade: No change.

1.2 Building condo ownership

Building is divided into (10) Tax Lots – 1201 to 1210:

- Mercantile Use: Consists of Tax Lot 1201, owned by Macy's Retail Holdings
- Business Use: Consists of Tax Lots 1202 and 1210, owned by 422 Fulton Owner, LLC.

1.3 Building Cores and Services

Business and Mercantile Use has separated elevators, and mostly separated services. Partial services and most egress stairs are shared by both,

Egress stairs:

- (6) set of egress stairs are shared (Stairs A, B, D, E, G and I)
- Stair K is exclusive to Business Use.
- Stair J is exclusive to Mercantile Use. Note there is a door on Cellar Mezzanine floor from the neighbor at 420 Fulton Street for egress easement.
- Some shared stairs do not reach the upper and lower below-grade floors.
- Stairs shafts are not pressurized

Elevators:

- Business Use has (3) elevator banks: A, B and C. A and B are Passenger Elevator banks. C is Service Elevator bank, which is also the Fire Access Elevator for the Business Use portion.
- Lobby of 181 Livingston open into Bank A. Lobby of 179 Livingston open into Bank B. Banks A and B are linked with doors. Both lobbies can access Bank C.
- Bank A serves the Offices and stops are Floors 7 to 14. Two elevators in this bank go up to PH1.
- Bank B serves Higher Education, and stops are Floors 1, 5, 6 and 7
- Bank C serve both Offices and Higher Education. Stops are Sub-Cellar 1, Cellar Mezzanine, 1, 7-14 and PH1.
- Mercantile Use has (2) elevator banks: D and E. Both banks have front and/or rear entrances on selective floors, and it varies by floors.
- Some elevators punch through each other's floors as shafts. In those shafts for the Business Use elevators, doors are provided at selective floors to address blind shaft requirements.
-

2. Project Description

- 2.1 Address:** Project Address (DOB filing):
422 Fulton Street
Brooklyn, NY 11201
- Entrances for Mercantile Use:
Entrance on 422 Fulton Street, with additional entrances along Hoyt Street and Livingston Street. There is a loading dock entrance on Gallatin Place for Mercantile Use through neighbor easement.
- Entrances for Business Use (Office and Higher Education):
179 and 181 Livingston Street,
Brooklyn, NY 11201
- 179 is lobby to Higher Education use and 181 is lobby to Office use.
- 2.2 Block / Lot Number:** Block 156, Lot 1201 to 1210
- 2.3 Zoning:** Per ZR 101-04 and Zoning Map 16c
- C5-4
 - DB (Downtown Brooklyn Special District)
 - Fulton Mall Sub-district (Partial, within 100 feet of Fulton Street)
- 2.4 Permissible Uses** Use Groups 1 through 6, plus 9, 10 and 11 (per ZR 32-10)
- Proposed uses:
- Office and Higher Education: Use Group 6B
 - Department Store: Use Group 10A
- 2.5 Flood Zone** Site does not lie within a Flood Hazard Area as designated by the Federal Emergency Management Agency Flood Insurance Rate Maps.
Community: City of New York.
- Map Number: 3604970203G, dated December 5, 2013
Map Number: 3604970203F, dated September 5, 2007
- 2.6 Streets:** Site is bound by the following paved streets, owned and maintained by the City of New York:
- North: Fulton Street (wide street)
 - East: Hoyt Street (narrow street)
 - South: Livingston Street (wide street)
 - West: Gallatin Place (narrow street)
- 2.7 Size:** Lot Area = 76, 094 sf
Gross building area = 985, 431 sf approximately

Fire Protection Plan Narrative

422 Fulton Street, Brooklyn, NY 11201

Date: July 27, 2022

2.8	Number of stories:	Above grade - (15), plus (2) mechanical penthouse levels and (1) mezzanine Below grade - (3), plus (2) mezzanines Within the Mercantile Use areas, there are selective rooms with mezzanines.
2.9	Building height	Top of highest occupied floor (PH1) is approximately 256'-6" above average curb height. Top of highest mechanical floor (PH3) is approximately 241'-6" above average curb height.
2.10	Occupancy Groups	Dominant Building Occupancy Groups: • E – Business (2014 Group B) • C – Mercantile (2014 Group M) Other occupancy groups: • B-1 – Storage (2014 Group S-1), Moderate hazard • B-2 = Storage (2014 Group S-2), Low hazard • D-2 – Industrial (2014 Group F-2), Low hazard • F-1b – Assembly (2014 Group A-1), Performance • F-3 – Assembly (2014 Group A-3), Exercise • F-4 – Assembly (2014 Group A-2), Food consumption
2.11	Construction Classification	I-C (Per Table 3-2, 1968 BCNYC)
2.12	Applicable Building Code:	1) 1968 Building Code of the City of New York With exceptions per 2014 New York City Construction Codes (Per §28-101.4.3 Optional Use of the 1968 Building Code for work on prior code buildings): 1. Fuel gas, plumbing and mechanical work. (2014 FGC, 2014 PC and 2014 MC) 2. Fire protection systems (2014 BC Ch.9) 3. Elevators, conveyors and amusement rides (2014 BC Ch.30 and Appendix K) 4. Safety during construction operations (2014 BC Ch.33) 5. Accessibility (2014 BC Ch.11) 6. Encroachments into the public right of way (2014 BC Ch.32) 7. Administration and enforcement (2014 General Administrative Provisions Ch.1) 8. Special inspections (2014 BC Ch.17) 9. Materials (2014 BC Ch.19-26) 10. Security grilles (2014 BC Section 1008.1.4.5) 11. Energy efficiency (2014 BC Ch.13) 12. Roof covering and replacements 12.1 Installation and materials (2014 BC Section 1510.1 through 1510.6) 12.2 Cool roofs (2014 BC Section 1504.9) 12.3 Green roofs (permitted per 2014 BC Ch.15) 13. Handrails (2014 BC Section 1009.12, 1010.8 and 1012) 14. Guards (2014 BC Section 1013 and 1607.7)

Fire Protection Plan Narrative

422 Fulton Street, Brooklyn, NY 11201

Date: July 27, 2022

**PERKINS —
EASTMAN**

15. Areas of special flood hazard (2014 BC Section 28-104.9.4 and Appendix G)
16. Structural (2014 BC Section 1601.2)
17. Emergency and standby power systems (2014 BC Section 2702.1)
18. Parking garages and open parking lots (2014 BC Section 406.2.11 or 406.7.11)
19. Mold protection (2014 BC Section 2506 and 2509)
- 2) 2014 New York City Construction Codes, for exceptions listed
- 3) 2014 New York City Energy Conservation Code (2014 BC 13.1.1.1)
- 4) 2010 ASHRAE 90.1 (as amended by 2014 ECC)
- 5) 2009 ANSI A117.1 (2014 BC 1101.2)
- 6) 2010 ADA Standards for Accessible Design
- 7) New York City Zoning Resolution
- 8) ASME A17.1 Safety Code for Elevators
- 9) 2014 New York City Fire Code

**2.13 Department of
Building
Application
Number:**

Business Use:

Base Building Core and Shell

Alteration 1:

Other related applications:

320908899

321407045

321358375

321401693

321407036

321358384

340425542

321401700

321750841

321358366

Tenant

2021-TMFALM-007189-PLAN

Mercantile Use:

321296986

321359864

321442355

321541300

321625452

321442364

321481222

321523231

321526327

321625461

321481231

321541293

321568246

321526354

321359864

321526292

321060374

340321208

340363145
340410120
321456857
340590275
340477013
340600683
321627165
340342506
302267099
FPIMS 36275360

**2.14 Fire
Protection
Plan
Application
Number:** To be assigned

3. Safety Systems and Features

3.1 Communications Systems:

Business (Office and Higher Education) Use:

The Fire alarm and Life Safety System shall be provided with two-way voice communication via fire alarm warden stations.

Mercantile Use

Previous existing Class “C” Fire Alarm system for the previous existing 10-story Mercantile Use building (before major renovation and addition for conversion to mixed-use building) was converted to a low-rise system per 2014 NYC Building Code: Manual and Automatic Smoke/Heat Detection and Sprinkler Fire Alarm System with One-Way Voice Communication. Reference FDNY letter dated June 6, 2017, FPIMS #36275360)

3.2 Alarm Systems:

Business (Office and Higher Education) Use:

The base building Fire Alarm and Life Safety System will be an addressable multiplex microprocessor base, electrically supervised fire alarm and voice communication system independent of the Building Management System (BMS), complete with central processor equipment, sensors, devices, data gathering transmission panels, console, conduit and wiring, etc.

The base building main fire alarm panel is located at the fire command station as per base building design and receives signals as required from the separate Macy’s fire alarm system. The fire alarm for base building and Macy’s are separate systems with a common interface to alert if one of the systems is activated.

The fire alarm system shall comply with the New York City Building Code and NFPA requirements and as directed by the local Fire Department officials.

Emergency voice/alarm communication system will be provided in accordance with the fire strategy. Visual notification will be provided in all public areas and common areas by fire alarm strobe appliances.

The fire alarm system will interface with other building systems such as security, IT, and BMS which may require to be shut down during a fire

Fire alarm devices shall be provided by the base building for all mechanical rooms, core rooms and egress stairs. Points of connection shall be provided to the fire alarm for connection of tenant fire alarm devices.

Mercantile Use

Previous existing Class “C” Fire Alarm system for the previous existing 10-story Mercantile Use building (before major renovation

and addition for conversion to mixed-use building) was converted to a low-rise system per 2014 NYC Building Code: Manual and Automatic Smoke/Heat Detection and Sprinkler Fire Alarm System with One-Way Voice Communication. Reference FDNY letter dated June 6, 2017, FPIMS #36275360)

3.3 Smoke and carbon monoxide detection equipment:

Business (Office and Higher Education) Use:

The Fire Alarm and Life Safety System will be Class 'B' non-coded, zoned, electrically supervised, Class 'A' backbone riser wiring, Class 'B' circuits, including, but not limited to the following:

- a. The fire detection and alarm system will be complete with manual pull stations, ceiling- mounted smoke detectors where required, duct mounted smoke detectors, heat detectors, warden stations and speaker/strobe devices.
- b. Sprinkler system water flow detection and valve position tamper switches.
- c. Automatic control of air handling systems under fire conditions.
- d. Automatic control of elevators under fire conditions.
- e. Manual control of smoke purge system.
- f. Fail safe door release system.
- g. Carbon monoxide detectors, with integral sounder bases, will be provided at loading dock, any corridor on the floor where the loading dock is located, as well as one floor above and one floor below per NYC Local Law 191 of 2018 and 1 RCNY 908-01.
- h. Class B fire alarm system will contain spare capacity for connection of tenant fire alarm devices.

Mercantile Use:

Previous existing Class "C" Fire Alarm system for the previous existing 10-story Mercantile Use building (before major renovation and addition for conversion to mixed-use building) was converted to a low-rise system per 2014 NYC Building Code: Manual and Automatic Smoke/Heat Detection and Sprinkler Fire Alarm System with One-Way Voice Communication. Reference FDNY letter dated June 6, 2017, FPIMS #36275360)

3.4 Location of fire command station:

Business and Mercantile Use has separate Fire Command Stations. Each Fire Command Station will display the status of the other.

Business (Office and Higher Education) Use:

A new manual and automatic fire alarm system with automatic smoke detection, Fire Department communication, two way communication, and emergency voice/ alarm communication will be installed throughout the new Office occupancy.

The Fire Command Station for Business Use will be located in the dedicated office lobby located on 181 Livingston Street. This Fire

Command Station will be connected to Department Store's existing Fire Command station for all supervisory, controls and alarming functions common to both systems as required. These common systems include the following: generator, fire pump, sprinkler pump and elevators.

First responders will respond to the Office address and Fire Command Station on 181 Livingston Street for events within the Business occupancy.

Mercantile Use:

Fire Command Station for Mercantile Use is existing and located within the Macy's retail area near Hoyt Street.

First responders will respond to the Macy's building address on 422 Fulton Street for events within the Retail occupancy.

3.5 Elevator recall:

Business (Office and Higher Education) and Mercantile Use:

Device activation on Business Use areas will recall Business Use elevators. Device activation on Mercantile Use areas will recall Mercantile Use elevators. The following activation will recall both Business and Mercantile elevators:

- Sprinkler waterflow activation on any below-grade floor, as building is served by a common sprinkler feed and fire pump.
- Sprinkler waterflow activation on 1st Floor, as building is served by a common sprinkler feed and fire pump.
- Smoke detector in Mercantile Use Elevator Machine Room on 10th floor. This EMR serves Mercantile elevators in Bank E, but is located within Business Use area.

Business Use:

Fireman's emergency operation shall be provided per code for Phase I and II modes.

Elevators shall return to 1st Floor, or automatically be disconnected after 90 seconds for later manual selection and evacuation, via activation of lobby detectors and/or recall switches for each group of elevators. System subsequently permits manual selection of any elevator in Fire Control Station.

Fire Control Panel is in the Fire/Security Room behind the Lobby Reception Desk at 181 Livingston, with duplicated functionality at the desk. Fire recall switches are adjacent to Fire Command Center at Reception Desk, and at Passenger Elevator Lobby.

Standby generator sized to run one elevator from each group and Fireman's Elevators simultaneously.

3.6 Emergency lighting and power:

Business Use (Office and Higher Education)

The emergency lighting system will comply with local codes. Emergency luminaires will be supplied from a dedicated system connected to the base building life safety emergency generator. Separate emergency lighting panels will be located in the electrical closets.

Illuminated exit signage will be provided through egress routes.

For emergency power provisions, please refer to response in section 3.9

Mercantile Use:

The emergency lighting system will comply with local codes. Emergency luminaires will be supplied from battery backup.

Illuminated exit signage will be provided through egress routes.

For emergency power provisions, please refer to response in section 3.9

3.7 Standpipes:

Business (Office and Higher Education) and Mercantile Use:

The new infrastructure will be installed at the Cellar level. Existing piping will be integrity tested and replaced as necessary.

The fire protection system will continue to be supplied from the existing fire water service on Hoyt Street along with a new fire water service from Fulton Street to serve the facility as described below.

- 6" fire service enters the facility at Hoyt Street at the Cellar Level. This service will be increased in diameter to 8".
- A new 8" fire service will be also installed at Fulton Street at the Cellar Level.
- These services will serve a new common supply header installed at the Cellar level.
- The common supply header will serve automatic fire pump and jockey pump.

The existing standpipe system is a class I system.

The facility will be served by a new common supply header at the Cellar Level. The common supply header will be supplied from the two (2) fire services as described above. The supply header will serve the new automatic fire pump and jockey pump.

The dedicated standpipe riser system is fed from the new main standpipe header at the Cellar Level up to the top of the facility by the new automatic fire pump.

The new dedicated standpipe system will be served by the new automatic fire pump and jockey pump. The standpipe system will

serve the entire facility, for Mercantile (M), and Business (B) occupancy. New standpipe risers will be installed as required and the existing risers will be extended to serve the expanded facility as required.

The existing Siamese connections for the facility will be maintained and connected to the new, reconfigured standpipe system. The locations are as follows:

- One (1) set FSP at Hoyt Street
- Two (2) sets FSP at Livingston Street
- Two (2) set FSP at Fulton Street

3.8 Sprinklers:

Business (Office and Higher Education) and Mercantile Use:

The new infrastructure will be installed at the Cellar level. Existing piping will be integrity tested and replaced as necessary.

The fire protection system will continue to be supplied from the existing sprinkler water service on Hoyt Street along with a new sprinkler water service from Fulton Street to serve the facility as described below.

- 6" sprinkler service enters the facility at Hoyt Street at the Cellar Level. This service will be increased in diameter to 8".
- A new 8" fire service will be also installed at Fulton Street at the Cellar Level.
- These services will serve a new common supply header installed at the Cellar level.

The facility will be served by a new common supply header at the Cellar Level. The common supply header will be supplied from the two (2) fire services as described above. The supply header will serve the new sprinklers.

The dedicated sprinkler riser system is fed from the new main sprinkler header at the Cellar Level up to the top of the facility by the new automatic sprinkler pump.

The new dedicated sprinkler system will be served by the new automatic sprinkler pump and jockey pump. The sprinkler system will serve the entire building, with Mercantile (M) and Business (B) occupancies. New sprinkler risers will be installed as required and the existing risers will be extended to serve the expanded facility as required.

The existing Siamese connections for the facility will be maintained and connected to the new, reconfigured sprinkler system. The locations are as follows:

- One (1) set Sprinkler at Hoyt Street
- Two (2) sets Sprinkler at Livingston Street
- One (1) set Sprinkler at Fulton Street

Sprinkler rigs will be provided on each floor, including water flow, tamper switches and testing / drain station. Code compliant temporary sprinkler loop shall be provided by Owner. A dry system shall be provided at the Business Use Loading Dock.

3.9 Emergency and standby power systems:

Business (Office and Higher Education) and Mercantile Use:

The life safety emergency power systems in the building will be supplied by a 1250kW generator. These systems will include the base building and tenant. Normal and emergency power distribution systems will be isolated from each other with automatic transfer switches (ATS).

This existing generator serves the following base building life safety emergency loads:

- Stair, exit and egress passageway lighting.
- Egress lighting.
- Fire alarm systems, including voice communications and alarm.
- First responder in building auxiliary radio communication system.
- Fire protection systems.
- Fire and sprinkler pumps.
- All elevator lighting and communication.

ATS and electrical panelboards will be provided to supply power to the legally required loads from the existing generator. The following legally required loads will be served from the existing generator:

- Elevators with power arranged so that any three elevators can be run on emergency power with selective operation limited to simultaneous operation of two elevators in each bank, plus freight elevator.

Business Use only:

Office and Higher Education Tenants:

In addition to the base building provided emergency/standby loads and legally required loads, there are some tenant optional standby loads that require generator back-up.

Mercantile Use only:

Department store will be provided with optional standby power for mechanical loads that require standby power from base building 1250 KW Generator.

3.10 Mechanical ventilation and air conditioning:

Business (Office and Higher Education) Use:

A combination general exhaust/post fire smoke purge exhaust system including fans and ducts risers is provided for building general exhaust and post-fire purge smoke exhaust requirements.

Resettable fire smoke dampers are located on each floor, which are connected to a master purge panel located within the existing fire command center.

Fusible link operated fire dampers are provided in penetrations for ducted and non-ducted air openings that require a 1-hr fire rating.

Fire smoke or smoke dampers are provided within smoke rated partitions, and also where devices need to be resettable by the building fire alarm system

Base building systems consist of packaged water cooled air handlers, providing heated and cooled air to new single duct, shutoff variable air flow boxes located around the floor plates.

Mercantile Use

A combination general exhaust/post fire smoke purge exhaust system including fans and ducts risers is provided for building general exhaust and post-fire purge smoke exhaust requirements. Resettable fire smoke dampers are located on each floor, which are connected to a master purge panel located within the existing fire command center.

Fusible link operated fire dampers are provided in penetrations for ducted and non-ducted air openings that require a 1-hr fire rating.

Fire smoke or smoke dampers are provided within smoke rated partitions, and also where devices need to be resettable by the building fire alarm system

3.11 Smoke control systems and equipment:

Business (Office and Higher Education) Use:

A combination general exhaust/post fire smoke purge exhaust system including fans and ducts risers is provided for building general exhaust and post-fire purge smoke exhaust requirements. Resettable fire smoke dampers are located on each floor, which are connected to a master purge panel located within the fire command center.

Mercantile Use

Local EMS Controller receives a localized dry connect input from the building fire system alarm panel. When the local EMS Controller receives the alarm input from the building fire system, purge mode is activated via internal programming. During purge mode, both Supply and Return fans VFD's are enabled and commanded to run at full speed (100%/60 Hertz.) Outside Air and Exhaust Dampers are commanded fully open. Return Air Damper is commanded fully closed. Local EMS Controller will continue to operate in purge mode until the local building fire

alarm input returns to normal state. When purge mode is deactivated, the system will resume its normal sequence of operation.

3.12 Furnishings types and materials:

Business Use:

Base Building Core and Shell:

There is no furnishing in base building scope. For interior finishes, exits, shafts and exit passageways where finished by Base Building will be Finish Class A, Smoke Developed Rating 25

Higher Education Tenant:

For interior finishes, exits, shafts and exit passageways finished by Higher Education Tenant will be Finish Class A, Smoke Developed Rating 25

3.13 Places of Assembly

Business Use:

Base Building Core and Shell:

There will be a Place of Assembly on Penthouse 1 level:

- Outdoor Tenant Amenity Area. Occupancy Use is Type F-4 Assembly with consumption of food and drinks (2014 Group A-2). Place of Assembly Certificate of Operation will be filed.

Higher Education Tenant:

There will be Place of Assembly on 5th Floor:

- Cafeteria. Occupancy Use is Type F-4 Assembly with consumption of food and drinks (2014 Group A-2).
- Auditorium. Occupancy Use is Type F-1b Assembly with performance (2014 Group A-1).
- Place of Assembly Certificate of Operation will be filed.

3.14 Fire department access:

Business (Office and Higher Education) and Mercantile Use:

Fire Department access and Fire Command Center for Office and Higher Education will be on 181 Livingston Street.

Mercantile Use

Official Address for Mercantile Use is 422 Fulton Street, and the Fire Command Center is allocated along Hoyt Street.

3.15 Photoluminescent pathway markings:

Business (Office and Higher Education) and Mercantile Use:

Photoluminescent pathway markings will be installed per Local Law 26 of 2004 and New York City Building Code § 27-383(b).
New York City Building Code Reference Standard RS 6-1 and 6-1A

Mercantile Use

Photoluminescent pathway markings will be installed per Local Law 26 of 2004 and New York City Building Code § 27-383(b).
New York City Building Code Reference Standard RS 6-1 and 6-1A

3.16 Other safety related systems, required and voluntary, to be installed:

N/A

3.17 Fire Protection Notes:

Business Use:

Base Building Core and Shell:

New rated construction shall be UL-Listed or equivalent assembly of spray-on medium density fireproofing, gypsum board assembly or concrete encasement. Existing rated construction meeting required fire rating per previous Construction Classification shall remain in-place, and repaired to maintain the required fire rating if damaged.

Any penetration through fire rated construction shall be fire-stopped per code requirements.

Partial west façades and east façades within 30' of property line are fire rated to meet code requirements.

Higher Education Tenant:

With Tenant fit-out areas, closely spaced sprinklers and smoke baffles were provided at selective partitions where 1 hour rated partitions are required. Approved CCD1 filed separately by Tenant Architect.

Mercantile Use:

There is no fire rated separation in Mercantile areas for Stock Rooms, Mechanical Rooms, etc.

General Note:

The NE corner of the building (as indicated by hatch on Fire Protection Plan drawings) from 1st Floor Mezzanine down is in development. It is excluded from this Fire Protection Plan submission.

**422 FULTON STREET
BROOKLYN, NY 11216**

FULTON STREET

GALLATIN PLACE

HOYT STREET

LIVINGSTON STREET

MERCANTILE / MACY'S (MAIN) ENTRY 422 FULTON STREET

STAIRWELL A

ELEVATOR BLANK E

STAIRWELL B

STAIRWELL C

STAIRWELL D

STAIRWELL E

STAIRWELL F

STAIRWELL G

STAIRWELL H

STAIRWELL I

STAIRWELL J

STAIRWELL K

STAIRWELL L

STAIRWELL M

STAIRWELL N

STAIRWELL O

STAIRWELL P

STAIRWELL Q

STAIRWELL R

STAIRWELL S

STAIRWELL T

STAIRWELL U

STAIRWELL V

STAIRWELL W

STAIRWELL X

STAIRWELL Y

STAIRWELL Z

ELEVATOR BLANK A

ELEVATOR BLANK B

ELEVATOR BLANK C

ELEVATOR BLANK D

ELEVATOR BLANK F

ELEVATOR BLANK G

ELEVATOR BLANK H

ELEVATOR BLANK I

ELEVATOR BLANK J

ELEVATOR BLANK K

ELEVATOR BLANK L

ELEVATOR BLANK M

ELEVATOR BLANK N

ELEVATOR BLANK O

ELEVATOR BLANK P

ELEVATOR BLANK Q

ELEVATOR BLANK R

ELEVATOR BLANK S

ELEVATOR BLANK T

ELEVATOR BLANK U

ELEVATOR BLANK V

ELEVATOR BLANK W

ELEVATOR BLANK X

ELEVATOR BLANK Y

ELEVATOR BLANK Z

ACCESS STAIR

ESCALATOR

ESCALATORS

DOWN TO CELLAR


UP TO 2ND FLOOR

OFFICE ENTRY 181 LIVINGSTON STREET MAIN ENTRANCE

MERCANTILE / MACY'S (TERTIARY) ENTRY 422 FULTON STREET

MERCANTILE / MACY'S (SECONDARY) ENTRY 422 FULTON STREET

LEGEND					
	Elevator	EMR	Elevator Machine Room		
	Elevator Blind Shaft	FCS	Fire Command Station		
	Stair	SP	Standpipe Outlet		
	Mechanical Equipment Room		Combination Connection		

 

FIRE SAFETY AND EMERGENCY ACTION PLAN

422 FULTON STREET
BROOKLYN, NY 11216



120 West 31st Street - 7TH FLOOR
NEW YORK, N.Y. 10001
PHONE NO: (212) 444-8786
EMAIL: INFO@TOWERCE.COM
WWW.TOWERCE.COM

LEGEND:

	STANDPIPE OS&Y ISOLATION VALVE		EVACUATION ROUTE
	SPRINKLER OS&Y ISOLATION VALVE		IN-BUILDING RELOCATION AREA
	STANDPIPE/ SPRINKLER ISOLATION VALVE		ELEVATOR CAR & NUMBER DESIGNATION
	SPRINKLER SHUTOFF VALVE		MECHANICAL / ELECTRICAL SPACES
	FIRE COMMAND CENTER		CONVENIENCE / ACCESS STAIR
	3 WAY ROOF MANIFOLD		ELEVATOR BLIND SHAFT/ MECHANICAL SHAFT
	WARDEN STATION PHONES		STAIR WELLS
	FIRE PUMP/ JOCKEY PUMP		NO ACCESS STAIRWELL
	FDNY CONNECTION COMBINATION SPK/STP		NO ACCESS CONVENIENCE / ACCESS STAIR

BUILDING NOTES

- XXXXXXXXXXXXXXXXXXXXX
- XXXXXXXXXXXXXXXXXXXXX
XXXXXXXXXXXXXXXXXXXXX

THESE DRAWINGS ARE THE PROPERTY OF TOWER CONSULTING ENGINEERS (TCE). THEY MAY NOT BE COPIED, REPRODUCED, ALTERED OR DISTRIBUTED WITHOUT WRITTEN CONSENT FROM TCE. THESE PLANS SHALL BE USED FOR ONLY THE WORK TYPE INDICATED ON THE DRAWINGS. LICENSED CONTRACTOR(S)/VENDOR(S) SHALL CONFIRM ALL FIELD CONDITIONS INCLUDING BUT NOT LIMITED TO LOCATION, DIMENSIONS, APPLICABLE CODES FROM ALL AUTHORITIES HAVING JURISDICTION (AHJ) AND LAWS ENACTED PRIOR TO INITIATING ANY WORK AND NOTIFY TCE OF ANY CONFLICTS, DISCREPANCIES, ERRORS, AND OMISSIONS WITNESSED IN WRITING. INSTALLATION OF ANY SCOPE INDICATED ON THE DRAWINGS SHALL NOT COMMENCE UNTIL THE AHJ APPROVES ANY AND ALL SCOPES SHOWN. THIS APPROVAL SHALL BE INDICATED ON THE PLANS VIA AN APPROVAL STAMP. TCE SHALL BE DEEMED AS THE AUTHOR OF THESE DRAWINGS AND SHALL RETAIN ALL STATUTORY, COMMON LAWS, EDUCATION LAWS, AND ANY OTHER RESERVED RIGHTS INCLUDING COPYRIGHT. THE OWNER OF THE PREMISES SHALL BE ALLOWED TO RETAIN COPIES OF THE DRAWINGS, SPECIFICATIONS, AND OTHER DOCUMENTS FOR THIS PROJECT ONLY FOR THE WORK INDICATED ON THE DRAWINGS.

SEAL & SIGNATURE

AHJ STAMP

PROJECT NAME AND ADDRESS :

422 FULTON STREET
BROOKLYN, NY 11216

TITLE :


LEGEND

FDNY RECORD ID #:

2022-EPPGFS-XXXXXX-PLAN

DATE: 07/13/2022
TCE JOB NUMBER: TISHAYK02
DRAWING BY: RAH
CHECK BY: MMZ
TCE TEAM LEAD: GIK
PROJECT MANAGER: ATY
DRAWING NUMBER:

NORTH ARROW

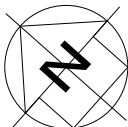


A-2

SHEET:01 OF 27

GALLATIN PLACE

FULTON STREET

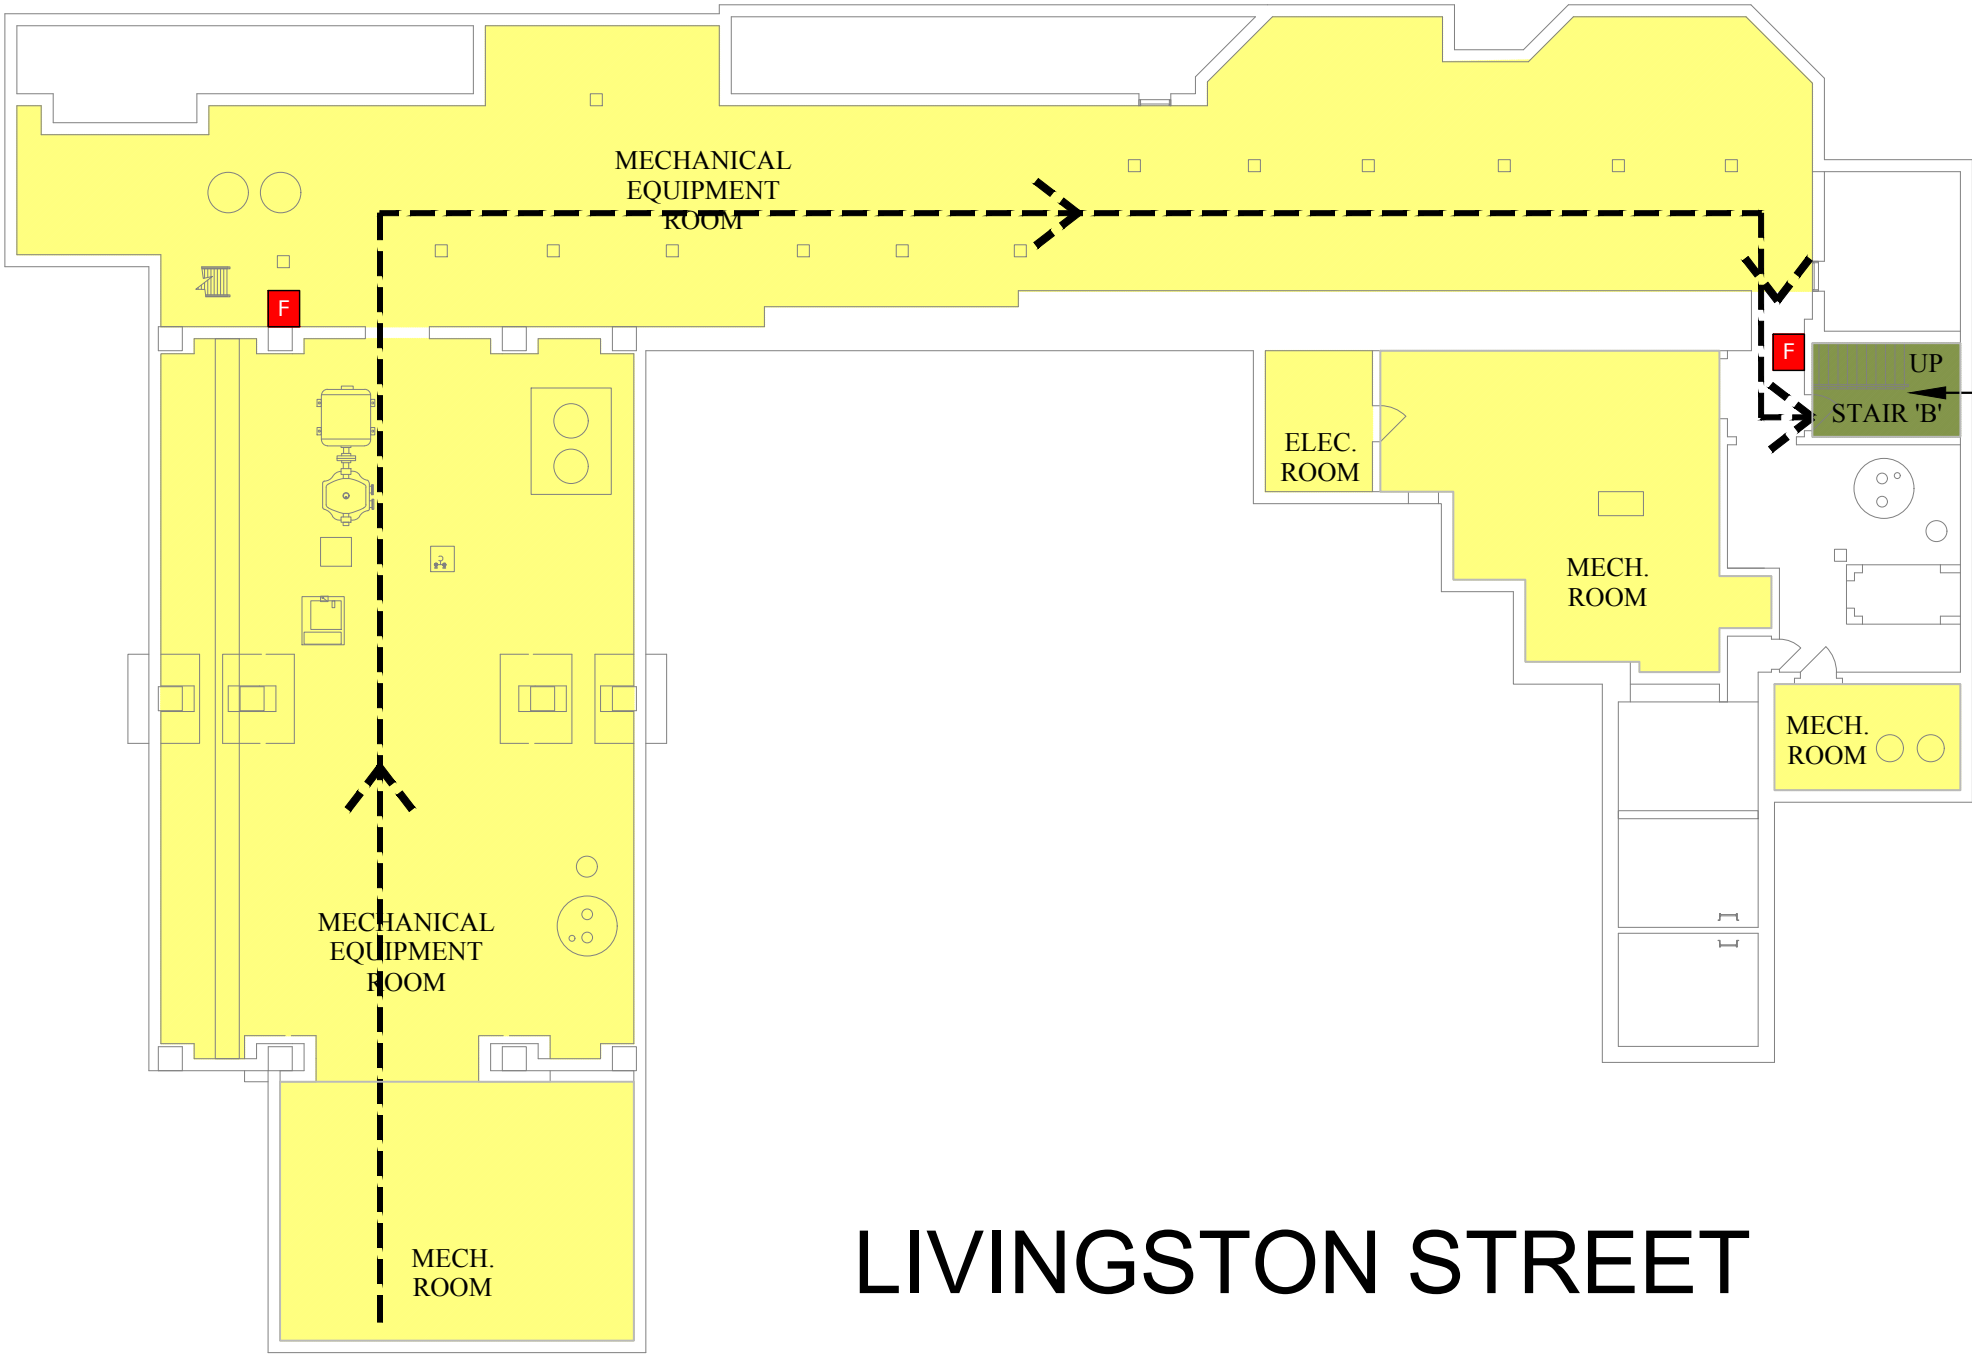

LIVINGSTON STREET

HOYT STREET

STAIRWELL
"B"



TOWER
CONSULTING ENGINEERS

120 West 31st Street - 7TH FLOOR
NEW YORK, N.Y. 10001
PHONE NO: (212) 444-8786
EMAIL: INFO@TOWERCE.COM
WWW.TOWERCE.COM

THESE DRAWINGS ARE THE PROPERTY OF TOWER CONSULTING ENGINEERS (TCE). THEY MAY NOT BE COPIED, REPRODUCED, ALTERED OR DISTRIBUTED WITHOUT WRITTEN CONSENT FROM TCE. THESE PLANS SHALL BE USED FOR ONLY THE WORK TYPE INDICATED ON THE DRAWINGS. LICENSED CONTRACTOR(S)/VENDOR(S) SHALL CONFIRM ALL FIELD CONDITIONS INCLUDING BUT NOT LIMITED TO LOCATION, DIMENSIONS, APPLICABLE CODES FROM ALL AUTHORITIES HAVING JURISDICTION (AHJ) AND LAWS ENACTED PRIOR TO INITIATING ANY WORK AND NOTIFY TCE OF ANY CONFLICTS, DISCREPANCIES, ERRORS, AND OMISSIONS WITNESSED IN WRITING. INSTALLATION OF ANY SCOPE INDICATED ON THE DRAWINGS SHALL NOT COMMENCE UNTIL THE AHJ APPROVES ANY AND ALL SCOPES SHOWN. THIS APPROVAL SHALL BE INDICATED ON THE PLANS VIA AN APPROVAL STAMP. TCE SHALL BE DEEMED AS THE AUTHOR OF THESE DRAWINGS AND SHALL RETAIN ALL STATUTORY, COMMON LAWS, EDUCATION LAWS, AND ANY OTHER RESERVED RIGHTS INCLUDING COPYRIGHT. THE OWNER OF THE PREMISES SHALL BE ALLOWED TO RETAIN COPIES OF THE DRAWINGS, SPECIFICATIONS, AND OTHER DOCUMENTS FOR THIS PROJECT ONLY FOR THE WORK INDICATED ON THE DRAWINGS.

SEAL & SIGNATURE

AHJ STAMP

PROJECT NAME AND ADDRESS :

422 FULTON STREET
BROOKLYN, NY 11216

 
TITLE :

SUB CELLAR 2 FLOOR PLAN

FDNY RECORD ID #:

2022-EPPGFS-XXXXXX-PLAN

DATE: 07/13/2022
TCE JOB NUMBER: TISHAYK02
DRAWING BY: RAH
CHECK BY: MMZ
TCE TEAM LEAD: GIK
PROJECT MANAGER: ATY
DRAWING NUMBER:



A-3

SHEET:02 OF 27

LEGEND:

PULL STATION	STANDPIPE/ SPRINKLER ISOLATION VALVE	FDNY CONNECTION COMBINATION	IN-BUILDING RELOCATION AREA	MECHANICAL/ELECTRICAL SPACES (MER)	
FIRE HOSE OUTLET	SPRINKLER FLOOR CONTROL VALVE	EVACUATION ROUTE	ELEVATOR CAR & NUMBER DESIGNATION	ELEVATOR BLIND SHAFT	
WARDEN STATION	SPRINKLER OS&Y SECTION VALVE	CONCRETE WALL	STAIRWELL	NO ACCESS STAIRWELL	
FIRE COMMAND STATION	STANDPIPE ISOLATION VALVE		CONVENIENCE/ ACCESS STAIRS		
FIRE PUMP/ JOCKEY PUMP	3 WAY MANIFOLD				



TOWER
CONSULTING ENGINEERS

120 West 31st Street - 7TH FLOOR
NEW YORK, N.Y. 10001
PHONE NO: (212) 444-8786
EMAIL: INFO@TOWERCE.COM
WWW.TOWERCE.COM

X	XX-XX-XXXX	XXXXXXXXXXXX
NO.	DATE	DETAILS

THESE DRAWINGS ARE THE PROPERTY OF TOWER CONSULTING ENGINEERS (TCE). THEY MAY NOT BE COPIED, REPRODUCED, ALTERED OR DISTRIBUTED WITHOUT WRITTEN CONSENT FROM TCE. THESE PLANS SHALL BE USED FOR ONLY THE WORK TYPE INDICATED ON THE DRAWINGS. LICENSED CONTRACTOR(S)/VENDOR(S) SHALL CONFIRM ALL FIELD CONDITIONS INCLUDING BUT NOT LIMITED TO LOCATION, DIMENSIONS, APPLICABLE CODES FROM ALL AUTHORITIES HAVING JURISDICTION (AHJ) AND LAWS ENACTED PRIOR TO INITIATING ANY WORK AND NOTIFY TCE OF ANY CONFLICTS, DISCREPANCIES, ERRORS, AND OMISSIONS WITNESSED IN WRITING. INSTALLATION OF ANY SCOPE INDICATED ON THE DRAWINGS SHALL NOT COMMENCE UNTIL THE AHJ APPROVES ANY AND ALL SCOPES SHOWN. THIS APPROVAL SHALL BE INDICATED ON THE PLANS VIA AN APPROVAL STAMP. TCE SHALL BE DEEMED AS THE AUTHOR OF THESE DRAWINGS AND SHALL RETAIN ALL STATUTORY, COMMON LAWS, EDUCATION LAWS, AND ANY OTHER RESERVED RIGHTS INCLUDING COPYRIGHT. THE OWNER OF THE PREMISES SHALL BE ALLOWED TO RETAIN COPIES OF THE DRAWINGS, SPECIFICATIONS, AND OTHER DOCUMENTS FOR THIS PROJECT ONLY FOR THE WORK INDICATED ON THE DRAWINGS.

SEAL & SIGNATURE

AHJ STAMP

PROJECT NAME AND ADDRESS:

422 FULTON STREET
BROOKLYN, NY 11216

TITLE:


SUB CELLAR FLOOR PLAN

FDNY RECORD ID #:

2022-EPPGFS-XXXXXX-PLAN

DATE:	07/13/2022
TCE JOB NUMBER:	TISHAYK02
DRAWING BY:	RAH
CHECK BY:	MMZ
TCE TEAM LEAD:	GJK
PROJECT MANAGER:	ATY
DRAWING NUMBER:	

NORTH ARROW

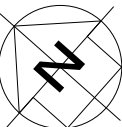

A-4

SHEET:03OF 27

FULTON STREET


GALLATIN PLACE

HOYT STREET

LIVINGSTON STREET

LEGEND:

F	PULL STATION	STANDPIPE/ SPRINKLER ISOLATION VALVE	FDNY CONNECTION COMBINATION	IN-BUILDING RELOCATION AREA	MECHANICAL/ELECTRICAL SPACES (MER)
FIRE HOSE OUTLET	FIRE HOSE OUTLET	SPRINKLER FLOOR CONTROL VALVE	EVACUATION ROUTE	ELEVATOR CAR & NUMBER DESIGNATION	ELEVATOR BLIND SHAFT
WARDEN STATION	WARDEN STATION	SPRINKLER OS&Y SECTION VALVE	CONCRETE WALL	STAIRWELL	NO ACCESS STAIRWELL
FIRE COMMAND STATION	FIRE COMMAND STATION	STANDPIPE ISOLATION VALVE		CONVENIENCE/ ACCESS STAIRS	
FIRE PUMP/ JOCKEY PUMP	FIRE PUMP/ JOCKEY PUMP	3 WAY MANIFOLD			

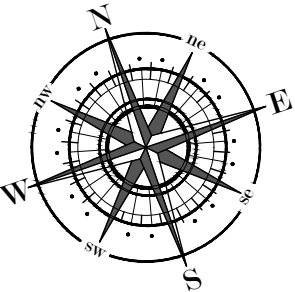



120 West 31st Street - 7TH FLOOR
NEW YORK, N.Y. 10001
PHONE NO: (212) 444-8786
EMAIL: INFO@TOWERCE.COM
WWW.TOWERCE.COM

X	XX-XX-XXXX	XXXXXXXXXXXX
NO.	DATE	DETAILS

THESE DRAWINGS ARE THE PROPERTY OF TOWER CONSULTING ENGINEERS (TCE). THEY MAY NOT BE COPIED, REPRODUCED, ALTERED OR DISTRIBUTED WITHOUT WRITTEN CONSENT FROM TCE. THESE PLANS SHALL BE USED FOR ONLY THE WORK TYPE INDICATED ON THE DRAWINGS. LICENSED CONTRACTOR(S)/VENDOR(S) SHALL CONFIRM ALL FIELD CONDITIONS INCLUDING BUT NOT LIMITED TO LOCATION, DIMENSIONS, APPLICABLE CODES, AND ALL OTHERS. ALL SUCH VERIFICATION SHALL BE DONE IN ACCORDANCE WITH ALL APPLICABLE LOCAL, STATE, AND FEDERAL LAWS ENACTED PRIOR TO INITIATING ANY WORK AND NOTIFY TCE OF ANY CONFLICTS, DISCREPANCIES, ERRORS, AND OMISSIONS WITNESSED IN WRITING. INSTALLATION OF ANY SCOPE INDICATED ON THE DRAWINGS SHALL NOT COMMENCE UNTIL THE AHI APPROVES ANY AND ALL SCOPES SHOWN. THIS APPROVAL SHALL BE INDICATED ON THE PLANS VIA AN APPROVAL STAMP. TCE SHALL BE DEEMED AS THE AUTHOR OF THESE DRAWINGS AND SHALL RETAIN ALL STATUTORY, COMMON LAW, AND FEDERAL LAWS, AND ALL OTHER RELEVANT RIGHTS, INCLUDING COPYRIGHT. THE OWNER OF THE PREMISES SHALL BE ALLOWED TO RETAIN COPIES OF THE DRAWINGS, SPECIFICATIONS, AND OTHER DOCUMENTS FOR THIS PROJECT ONLY FOR THE WORK INDICATED ON THE DRAWINGS.

SEAL & SIGNATURE

AHJ STAMP

PROJECT NAME AND ADDRESS :

422 FULTON STREET
BROOKLYN, NY 11216

TITLE :


CELLAR FLOOR PLAN

FDNY RECORD ID #:

2022-EPPGFS-XXXXXX-PLAN


DATE:	07/13/2022
TRACE JOB NUMBER:	TISHAYK0
DRAWING BY:	RAH
CHECK BY:	MM
TRACE TEAM LEAD:	GIR
PROJECT MANAGER:	ATY
DRAWING NUMBER:	

NORTH ARROW

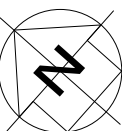

A-5

SHEET:04 OF 27

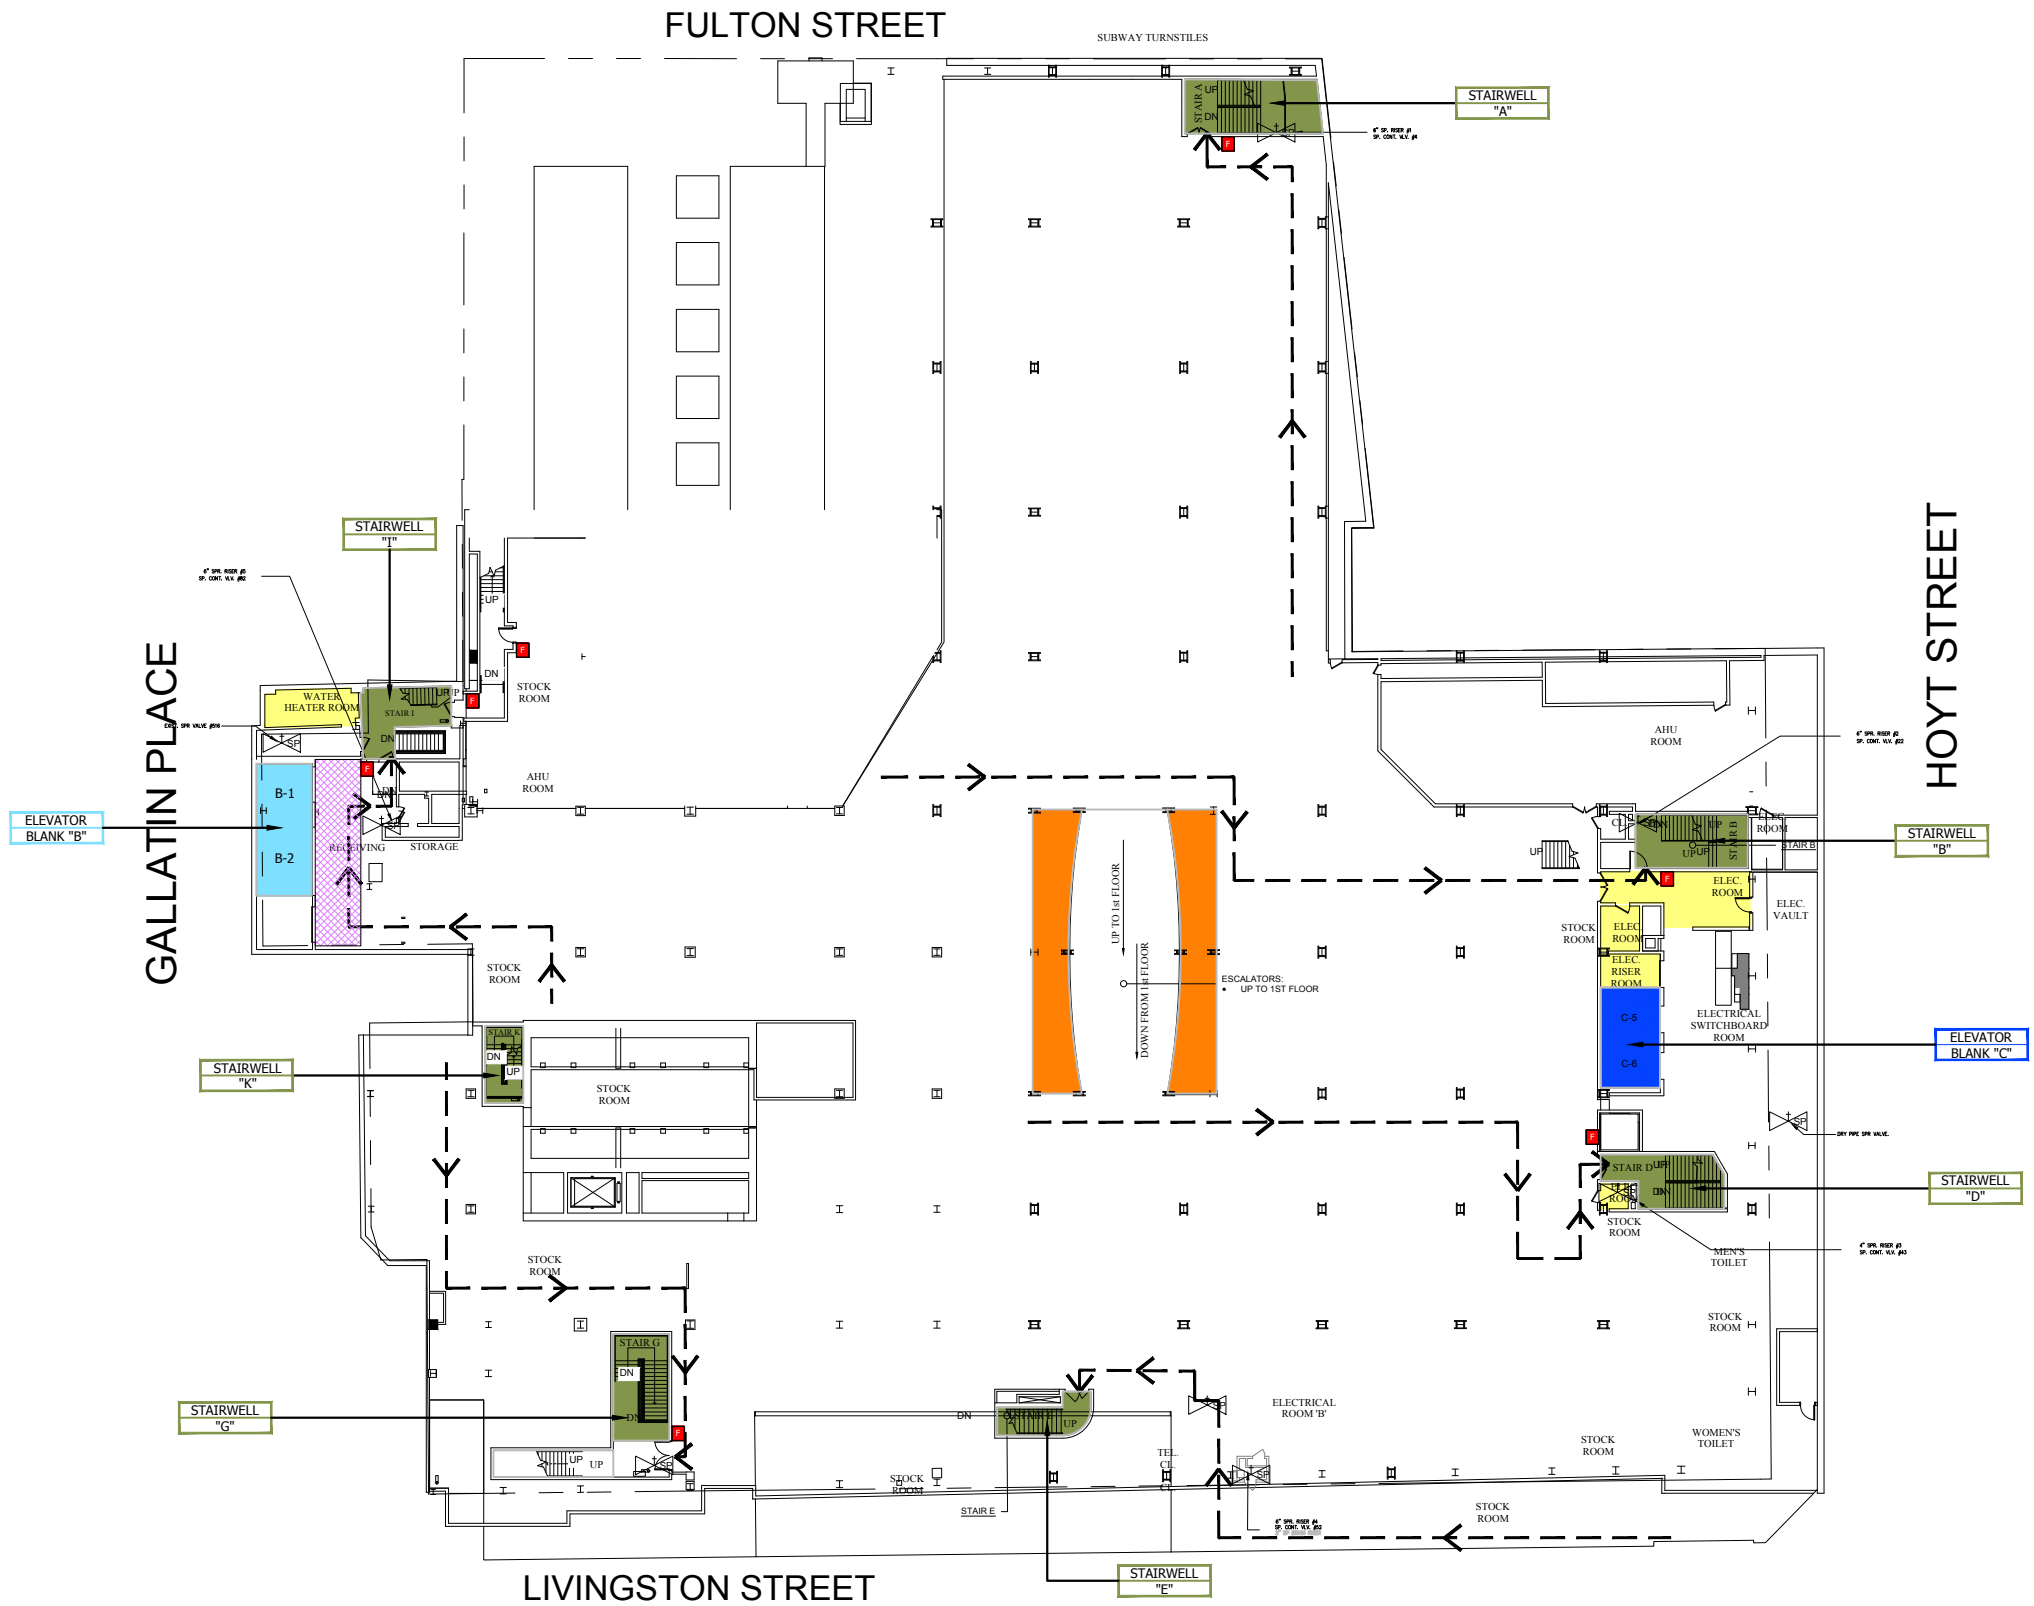

LEGEND:

 PULL STATION	 STANDPIPE/ SPRINKLER ISOLATION VALVE	 FDNY CONNECTION COMBINATION	 IN-BUILDING RELOCATION AREA  ELEVATOR CAR & NUMBER DESIGNATION  STAIRWELL  CONVENIENCE/ ACCESS STAIRS  MECHANICAL/ELECTRICAL SPACES (MER)  ELEVATOR BLIND SHAFT  NO ACCESS STAIRWELL	
 FIRE HOSE OUTLET	 SPRINKLER FLOOR CONTROL VALVE	 EVACUATION ROUTE		
 WARDEN STATION	 SPRINKLER OS&Y SECTION VALVE	 CONCRETE WALL		
 FIRE COMMAND STATION	 STANDPIPE ISOLATION VALVE			
 FIRE PUMP/ JOCKEY PUMP	 3 WAY MANIFOLD			



TOWER
CONSULTING ENGINEERS

120 West 31st Street - 7TH FLOOR
NEW YORK, N.Y. 10001
PHONE NO: (212) 444-8786
EMAIL: INFO@TOWERCE.COM
WWW.TOWERCE.COM

X	XX-XX-XXXX	XXXXXXXXXXXXX
NO.	DATE	DETAILS

THESE DRAWINGS ARE THE PROPERTY OF TOWER CONSULTING ENGINEERS (TCE). THEY MAY NOT BE COPIED, REPRODUCED, ALTERED OR DISTRIBUTED WITHOUT WRITTEN CONSENT FROM TCE. THESE PLANS SHALL BE USED FOR ONLY THE WORK TYPE INDICATED ON THE DRAWINGS. LICENSED CONTRACTOR(S)/VENDOR(S) SHALL CONFIRM ALL FIELD CONDITIONS INCLUDING BUT NOT LIMITED TO LOCATION, DIMENSIONS, APPLICABLE CODES FROM ALL AUTHORITIES HAVING JURISDICTION (AHJ) AND LAWS ENACTED PRIOR TO INITIATING ANY WORK AND NOTIFY TCE OF ANY CONFLICTS, DISCREPANCIES, ERRORS, AND OMISSIONS WITNESSED IN WRITING. INSTALLATION OF ANY SCOPE INDICATED ON THE DRAWINGS SHALL NOT COMMENCE UNTIL THE AHJ APPROVES ANY AND ALL SCOPES SHOWN. THIS APPROVAL SHALL BE INDICATED ON THE PLANS VIA AN APPROVAL STAMP. TCE SHALL BE DEEMED AS THE AUTHOR OF THESE DRAWINGS AND SHALL RETAIN ALL STATUTORY, COMMON LAWS, EDUCATION LAWS, AND ANY OTHER RESERVED RIGHTS INCLUDING COPYRIGHT. THE OWNER OF THE PREMISES SHALL BE ALLOWED TO RETAIN COPIES OF THE DRAWINGS, SPECIFICATIONS, AND OTHER DOCUMENTS FOR THIS PROJECT ONLY FOR THE WORK INDICATED ON THE DRAWINGS.

SEAL & SIGNATURE

AHJ STAMP

PROJECT NAME AND ADDRESS :

422 FULTON STREET
BROOKLYN, NY 11216

TITLE :


CELLAR MEZZ FLOOR PLAN

FDNY RECORD ID #:

2022-EPPGFS-XXXXXX-PLAN


DATE: 07/13/2022
TCE JOB NUMBER: TISHAYK02
DRAWING BY: RAH
CHECK BY: MMZ
TCE TEAM LEAD: GIK
PROJECT MANAGER: ATY
DRAWING NUMBER:

NORTH ARROW

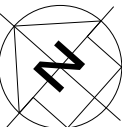

A-6

SHEET:05OF 27

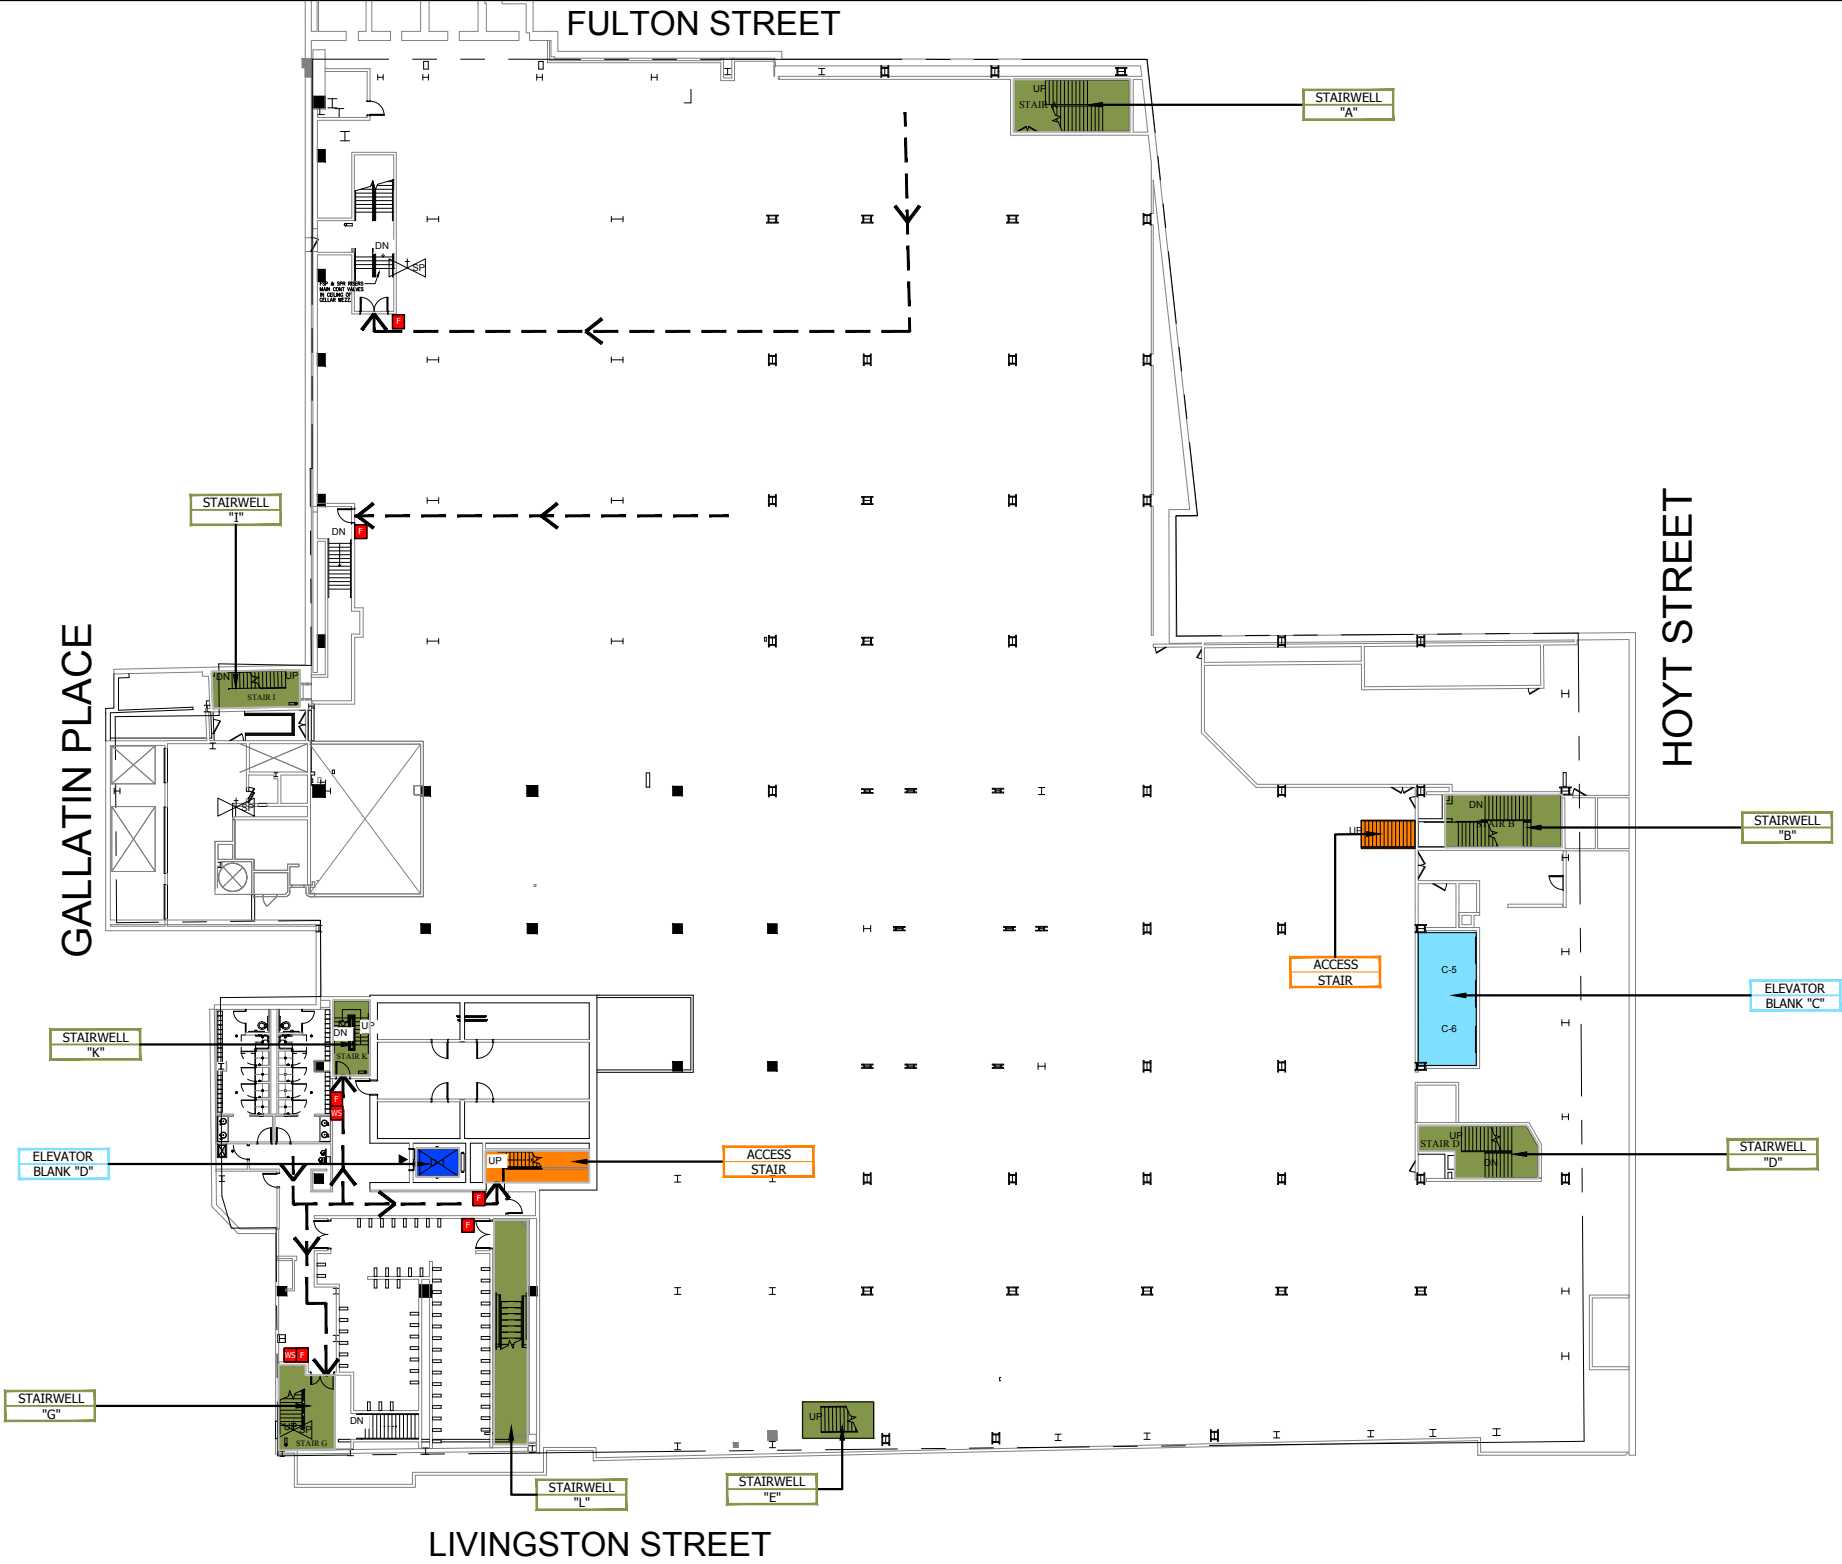

LEGEND:

PULL STATION	STANDPIPE/ SPRINKLER ISOLATION VALVE	FDNY CONNECTION COMBINATION	IN-BUILDING RELOCATION AREA	MECHANICAL/ELECTRICAL SPACES (MER)	
FIRE HOSE OUTLET	SPRINKLER FLOOR CONTROL VALVE	EVACUATION ROUTE	ELEVATOR CAR & NUMBER DESIGNATION	ELEVATOR BLIND SHAFT	
WARDEN STATION	SPRINKLER OS&Y SECTION VALVE	CONCRETE WALL	STAIRWELL	NO ACCESS STAIRWELL	
FIRE COMMAND STATION	STANDPIPE ISOLATION VALVE		CONVENIENCE/ ACCESS STAIRS		
FIRE PUMP/ JOCKEY PUMP	3 WAY MANIFOLD				


FIRE SAFETY AND EMERGENCY ACTION PLAN

422 FULTON STREET
BROOKLYN, NY 11216



TOWER
CONSULTING ENGINEERS

120 West 31st Street - 7TH FLOOR
NEW YORK, N.Y. 10001
PHONE NO: (212) 444-8786
EMAIL: INFO@TOWERCE.COM
WWW.TOWERCE.COM

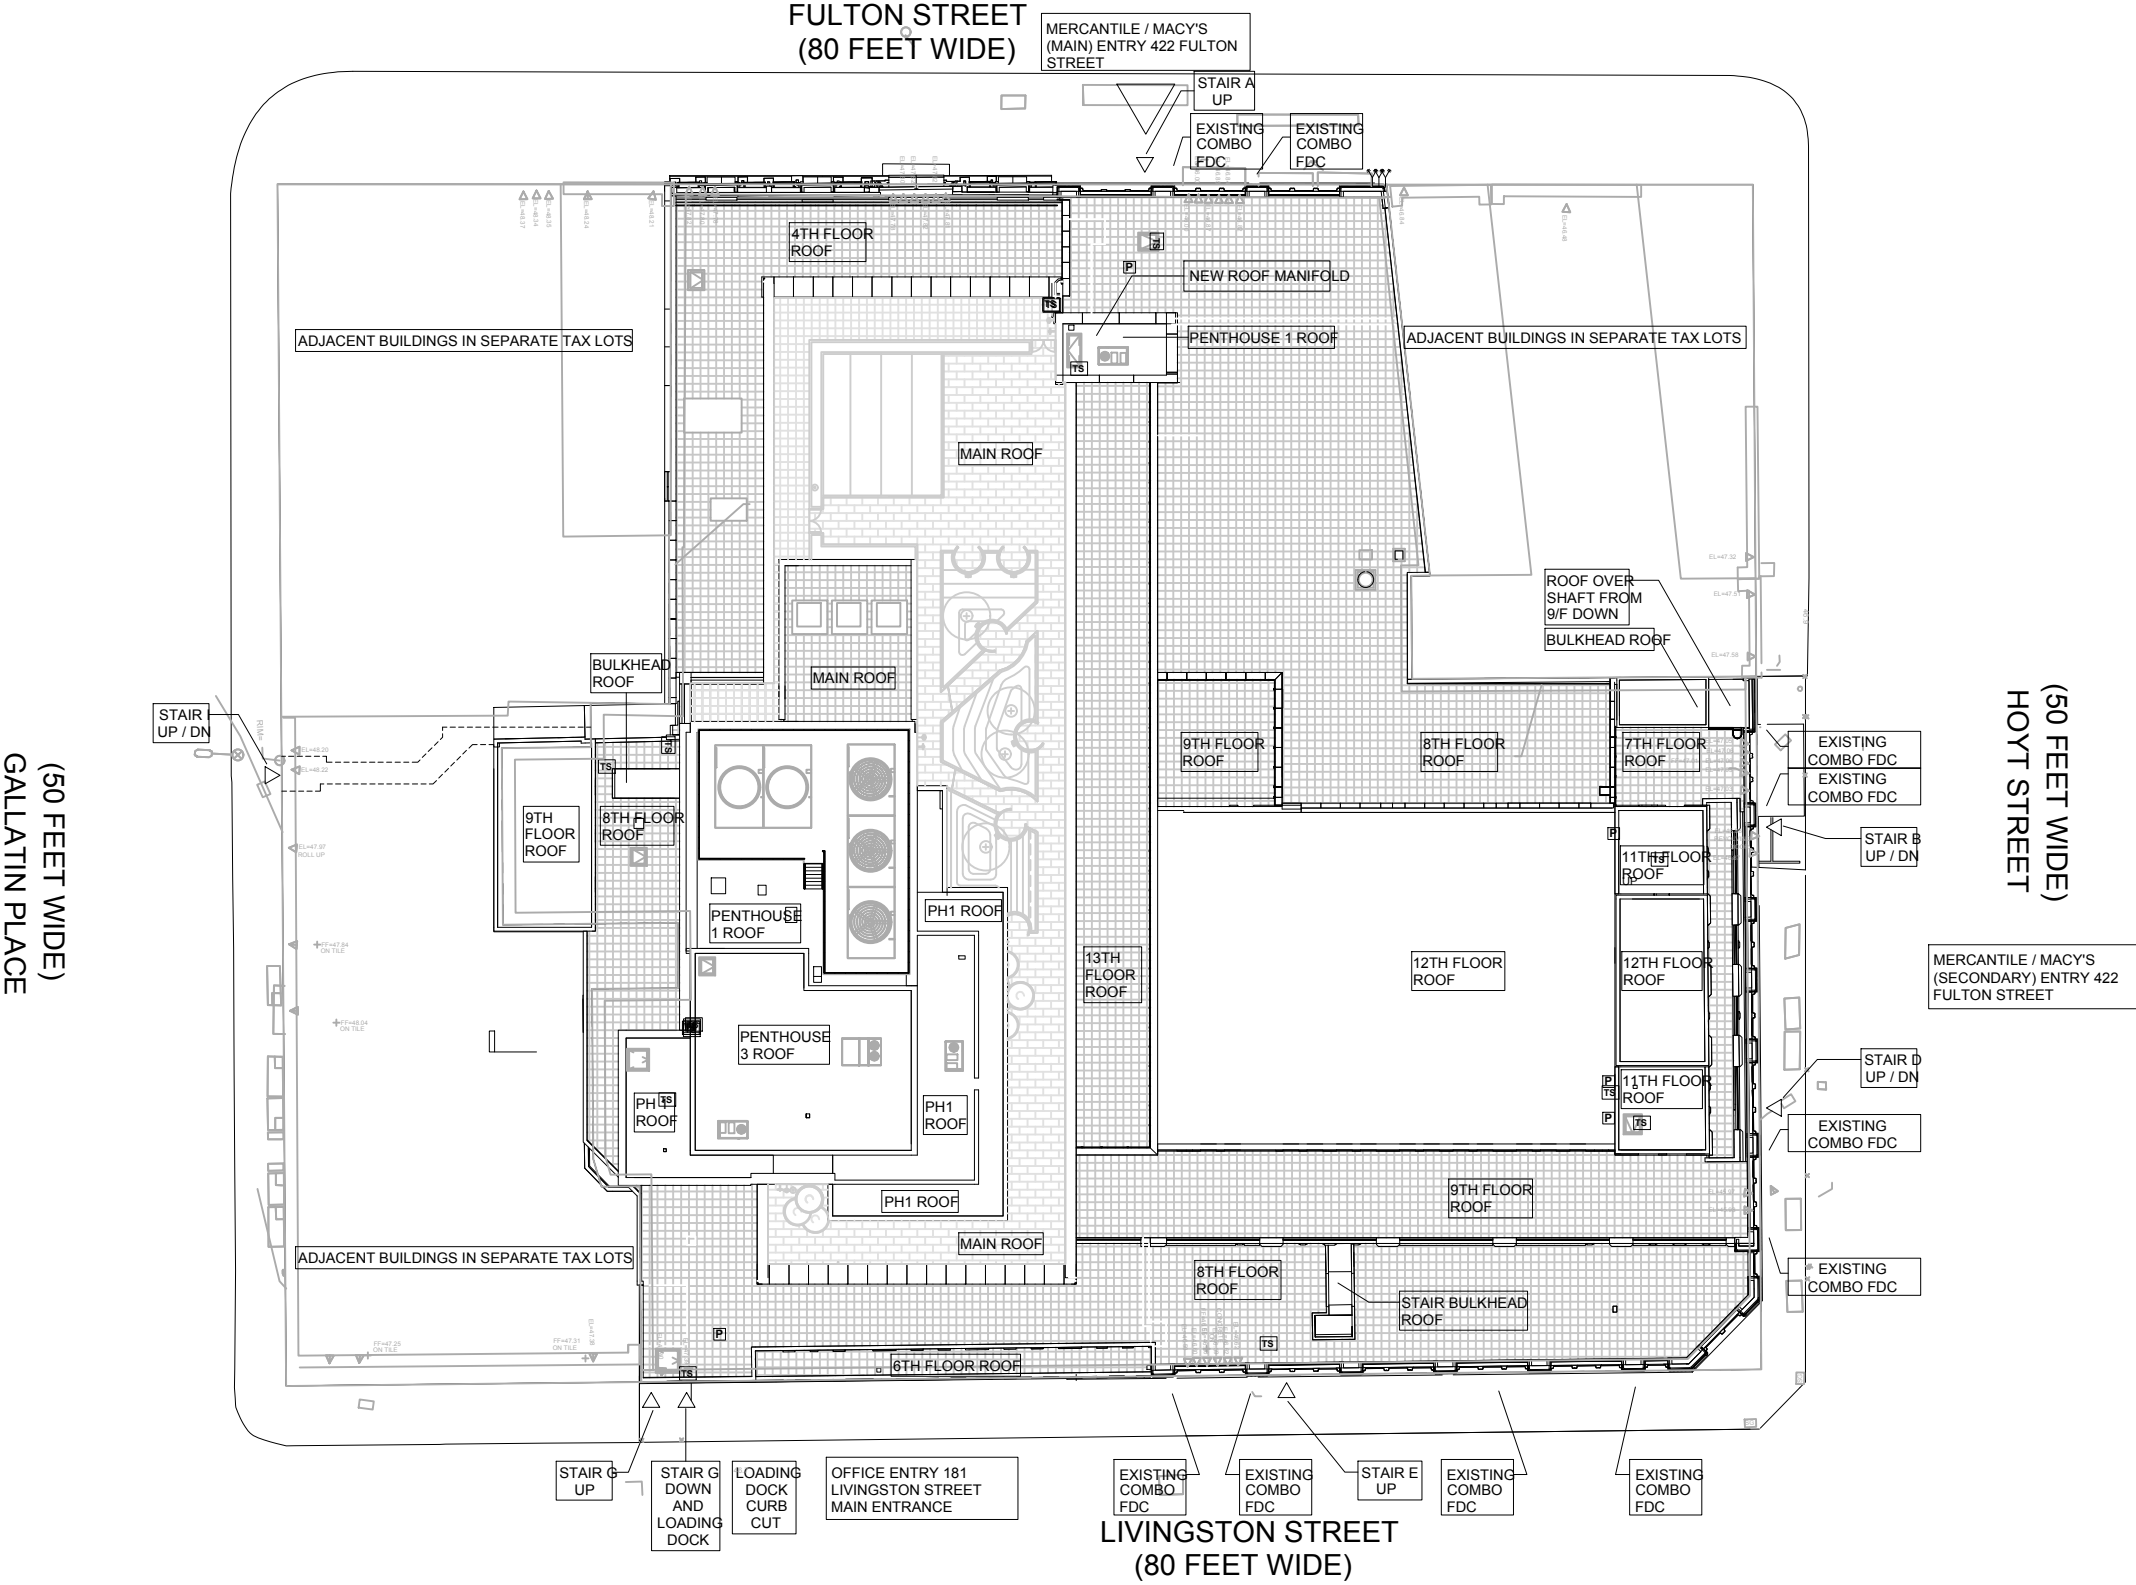

THESE DRAWINGS ARE THE PROPERTY OF TOWER CONSULTING ENGINEERS (TCE). THEY MAY NOT BE COPIED, REPRODUCED, ALTERED OR DISTRIBUTED WITHOUT WRITTEN CONSENT FROM TCE. THESE PLANS SHALL BE USED FOR ONLY THE WORK TYPE INDICATED ON THE DRAWINGS. LICENSED CONTRACTOR(S)/VENDOR(S) SHALL CONFIRM ALL FIELD CONDITIONS INCLUDING BUT NOT LIMITED TO LOCATION, DIMENSIONS, APPLICABLE CODES FROM ALL AUTHORITIES HAVING JURISDICTION (AHJ) AND LAWS ENACTED PRIOR TO INITIATING ANY WORK AND NOTIFY TCE OF ANY CONFLICTS, DISCREPANCIES, ERRORS, AND OMISSIONS WITNESSED IN WRITING. INSTALLATION OF ANY SCOPE INDICATED ON THE DRAWINGS SHALL NOT COMMENCE UNTIL THE AHJ APPROVES ANY AND ALL SCOPES SHOWN. THIS APPROVAL SHALL BE INDICATED ON THE PLANS VIA AN APPROVAL STAMP. TCE SHALL BE DEEMED AS THE AUTHOR OF THESE DRAWINGS AND SHALL RETAIN ALL STATUTORY, COMMON LAWS, EDUCATION LAWS, AND ANY OTHER RESERVED RIGHTS INCLUDING COPYRIGHT. THE OWNER OF THE PREMISES SHALL BE ALLOWED TO RETAIN COPIES OF THE DRAWINGS, SPECIFICATIONS, AND OTHER DOCUMENTS FOR THIS PROJECT ONLY FOR THE WORK INDICATED ON THE DRAWINGS.

SEAL & SIGNATURE

AHJ STAMP

PROJECT NAME AND ADDRESS:

422 FULTON STREET
BROOKLYN, NY 11216

TITLE:


SITE PLAN

FDNY RECORD ID #:

2022-EPPGFS-XXXXXX-PLAN

DATE: 07/13/2022
TCE JOB NUMBER: TISHAYK02
DRAWING BY: RAH
CHECK BY: MMZ
TCE TEAM LEAD: GIK
PROJECT MANAGER: ATY
DRAWING NUMBER:

NORTH ARROW

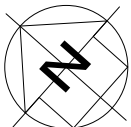

ST-1

SHEET:06OF 27

FIRE SAFETY AND EMERGENCY ACTION PLAN

422 FULTON STREET
BROOKLYN, NY 11216



TOWER
CONSULTING ENGINEERS

120 West 31st Street - 7TH FLOOR
NEW YORK, N.Y. 10001
PHONE NO: (212) 444-8786
EMAIL: INFO@TOWERCE.COM
WWW.TOWERCE.COM

IBRA TABLE CONTENTS (IN BUILDING RELOCATION AREA)

SHEET NO	DWG NO	TITLE	LOCATION	SHEET NO	DWG NO	TITLE	LOCATION
02 OF 27	A-3	SUB CELLAR 2 FLOOR PLAN	ELEVATOR LOBBY	25 OF 27	FL-20	PENTHOUSE 2	
03 OF 27	A-4	SUB CELLAR 1 FLOOR PLAN	ELEVATOR LOBBY	26 OF 27	FL-21	PENTHOUSE 3	
04 OF 27	A-5	CELLAR FLOOR PLAN	ELEVATOR LOBBY				
05 OF 27	A-6	CELLAR MEZZANINE FLOOR PLAN	ELEVATOR LOBBY				
09 OF 27	FL-4	1ST FLOOR	ELEVATOR LOBBY				
10 OF 27	FL-5	1ST FLOOR MEZZ	ELEVATOR LOBBY				
11 OF 27	FL-6	2ND FLOOR	ELEVATOR LOBBY				
12 OF 27	FL-7	3RD FLOOR	ELEVATOR LOBBY				
13 OF 27	FL-8	4TH FLOOR	ELEVATOR LOBBY				
14 OF 27	FL-9	5TH FLOOR	ELEVATOR LOBBY				
15 OF 27	FL-10	6TH FLOOR	ELEVATOR LOBBY				
16 OF 27	FL-11	7TH FLOOR	ELEVATOR LOBBY				
17 OF 27	FL-12	8TH FLOOR	ELEVATOR LOBBY				
18 OF 27	FL-13	9TH FLOOR	ELEVATOR LOBBY				
19 OF 27	FL-14	10TH FLOOR	ELEVATOR LOBBY				
20 OF 27	FL-15	11TH FLOOR	ELEVATOR LOBBY				
21 OF 27	FL-16	12TH FLOOR	ELEVATOR LOBBY				
22 OF 27	FL-17	13TH FLOOR	ELEVATOR LOBBY				
23 OF 27	FL-18	14TH FLOOR	ELEVATOR LOBBY				
24 OF 27	FL-19	PENTHOUSE 1/MAIN ROOG	ELEVATOR LOBBY				

THESE DRAWINGS ARE THE PROPERTY OF TOWER CONSULTING ENGINEERS (TCE). THEY MAY NOT BE COPIED, REPRODUCED, ALTERED OR DISTRIBUTED WITHOUT WRITTEN CONSENT FROM TCE. THESE PLANS SHALL BE USED FOR ONLY THE WORK TYPE INDICATED ON THE DRAWINGS. LICENSED CONTRACTOR(S)/VENDOR(S) SHALL CONFIRM ALL FIELD CONDITIONS INCLUDING BUT NOT LIMITED TO LOCATION, DIMENSIONS, APPLICABLE CODES FROM ALL AUTHORITIES HAVING JURISDICTION (AHJ) AND LAWS ENACTED PRIOR TO INITIATING ANY WORK AND NOTIFY TCE OF ANY CONFLICTS, DISCREPANCIES, ERRORS, AND OMISSIONS WITNESSED IN WRITING. INSTALLATION OF ANY SCOPE INDICATED ON THE DRAWINGS SHALL NOT COMMENCE UNTIL THE AHJ APPROVES ANY AND ALL SCOPES SHOWN. THIS APPROVAL SHALL BE INDICATED ON THE PLANS VIA AN APPROVAL STAMP. TCE SHALL BE DEEMED AS THE AUTHOR OF THESE DRAWINGS AND SHALL RETAIN ALL STATUTORY, COMMON LAWS, EDUCATION LAWS, AND ANY OTHER RESERVED RIGHTS INCLUDING COPYRIGHT. THE OWNER OF THE PREMISES SHALL BE ALLOWED TO RETAIN COPIES OF THE DRAWINGS, SPECIFICATIONS, AND OTHER DOCUMENTS FOR THIS PROJECT ONLY FOR THE WORK INDICATED ON THE DRAWINGS.

SEAL & SIGNATURE

AHJ STAMP

PROJECT NAME AND ADDRESS :

422 FULTON STREET
BROOKLYN, NY 11216


TITLE :

IBRA TABLE OF CONTENTS
(IN BUILDING RELOCATION AREA)

FDNY RECORD ID #:

2022-EPPGFS-XXXXXX-PLAN

DATE: 07/13/2022
TCE JOB NUMBER: TISHAYK02
DRAWING BY: RAH
CHECK BY: MMZ
TCE TEAM LEAD: GIK
PROJECT MANAGER: ATY
DRAWING NUMBER:

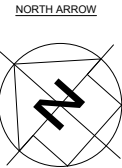

I-1

SHEET:07 OF 27

FIRE SAFETY AND EMERGENCY ACTION PLAN

422 FULTON STREET
BROOKLYN, NY 11216



120 West 31st Street - 7TH FLOOR
NEW YORK, N.Y. 10001
PHONE NO: (212) 444-8786
EMAIL: INFO@TOWERCE.COM
WWW.TOWERCE.COM

LIST OF DRAWINGS					
SHEET NO	DWG NO	TITLE	SHEET NO	DWG NO	TITLE
01 OF 27	A-2	LEGEND	21 OF 27	FL-13	12TH FLOOR PLAN
02 OF 27	A-3	SUB CELLAR 2 FLOOR PLAN	22 OF 27	FL-14	13TH FLOOR PLAN
03 OF 27	A-4	SUB CELLAR 2 FLOOR PLAN	23 OF 27	FL-15	14TH FLOOR PLAN
04 OF 27	A-5	CELLAR FLOOR PLAN	24 OF 27	FL-16	PENTHOUSE 1/MAIN ROOF
05 OF 27	A-6	CELLAR MEZZANINE FLOOR PLAN	25 OF 27	FL-17	PENTHOUSE 2
06 OF 27	ST-1	SITE PLAN	26 OF 27	FL-18	PENTHOUSE 3
07 OF 27	I-1	IBRA TABLE	27 OF 27	R-1	SPRINKLER/STANDPIPE RISER
08 OF 27	FL-0	DRAWING LIST			
09 OF 27	FL-1	FIRST FLOOR PLAN			
10 OF 27	FL-2	1ST FLOOR MEZZANINE FLOOR PLAN			
11 OF 27	FL-3	2ND FLOOR PLAN			
12 OF 27	FL-4	3RD FLOOR PLAN			
13 OF 27	FL-5	4TH FLOOR PLAN			
14 OF 27	FL-6	5TH FLOOR PLAN			
15 OF 27	FL-7	6TH FLOOR PLAN			
16 OF 27	FL-8	7TH FLOOR PLAN			
17 OF 27	FL-9	8TH FLOOR PLAN			
18 OF 27	FL-10	9TH FLOOR PLAN			
19 OF 27	FL-11	10TH FLOOR PLAN			
20 OF 27	FL-12	11TH FLOOR PLAN			

THESE DRAWINGS ARE THE PROPERTY OF TOWER CONSULTING ENGINEERS (TCE). THEY MAY NOT BE COPIED, REPRODUCED, ALTERED OR DISTRIBUTED WITHOUT WRITTEN CONSENT FROM TCE. THESE PLANS SHALL BE USED FOR ONLY THE WORK TYPE INDICATED ON THE DRAWINGS. LICENSED CONTRACTOR(S)/VENDOR(S) SHALL CONFIRM ALL FIELD CONDITIONS INCLUDING BUT NOT LIMITED TO LOCATION, DIMENSIONS, APPLICABLE CODES FROM ALL AUTHORITIES HAVING JURISDICTION (AHJ) AND LAWS ENACTED PRIOR TO INITIATING ANY WORK AND NOTIFY TCE OF ANY CONFLICTS, DISCREPANCIES, ERRORS, AND OMISSIONS WITNESSED IN WRITING. INSTALLATION OF ANY SCOPE INDICATED ON THE DRAWINGS SHALL NOT COMMENCE UNTIL THE AHJ APPROVES ANY AND ALL SCOPES SHOWN. THIS APPROVAL SHALL BE INDICATED ON THE PLANS VIA AN APPROVAL STAMP. TCE SHALL BE DEEMED AS THE AUTHOR OF THESE DRAWINGS AND SHALL RETAIN ALL STATUTORY, COMMON LAWS, EDUCATION LAWS, AND ANY OTHER RESERVED RIGHTS INCLUDING COPYRIGHT. THE OWNER OF THE PREMISES SHALL BE ALLOWED TO RETAIN COPIES OF THE DRAWINGS, SPECIFICATIONS, AND OTHER DOCUMENTS FOR THIS PROJECT ONLY FOR THE WORK INDICATED ON THE DRAWINGS.

SEAL & SIGNATURE

AHJ STAMP

PROJECT NAME AND ADDRESS :

422 FULTON STREET
BROOKLYN, NY 11216

 
TITLE :

DRAWING LIST

FDNY RECORD ID #:

2022-EPPGFS-XXXXXX-PLAN

DATE: 07/13/2022
TCE JOB NUMBER: TISHAYK02
DRAWING BY: RAH
CHECK BY: MMZ
TCE TEAM LEAD: GIK
PROJECT MANAGER: ATY
DRAWING NUMBER:



FL-0

SHEET:08OF 27



TOWER
CONSULTING ENGINEERS

120 West 31st Street - 7TH FLOOR
NEW YORK, N.Y. 10001
PHONE NO: (212) 444-8786
EMAIL: INFO@TOWERCE.COM
WWW.TOWERCE.COM

X	XX-XX-XXXX	XXXXXXXXXXXXX
NO.	DATE	DETAILS

THESE DRAWINGS ARE THE PROPERTY OF TOWER CONSULTING ENGINEERS (TCE). THEY MAY NOT BE COPIED, REPRODUCED, ALTERED OR DISTRIBUTED WITHOUT WRITTEN CONSENT FROM TCE. THESE PLANS SHALL BE USED FOR ONLY THE WORK TYPE INDICATED ON THE DRAWINGS. LICENSED CONTRACTOR(S)/VENDOR(S) SHALL CONFIRM ALL FIELD CONDITIONS INCLUDING BUT NOT LIMITED TO LOCATION, DIMENSIONS, APPLICABLE CODES FROM ALL AUTHORITIES HAVING JURISDICTION (AHJ) AND LAWS ENACTED PRIOR TO INITIATING ANY WORK AND NOTIFY TCE OF ANY CONFLICTS, DISCREPANCIES, ERRORS, AND OMISSIONS WITNESSED IN WRITING. INSTALLATION OF ANY SCOPE INDICATED ON THE DRAWINGS SHALL NOT COMMENCE UNTIL THE AHJ APPROVES ANY AND ALL SCOPES SHOWN. THIS APPROVAL SHALL BE INDICATED ON THE PLANS VIA AN APPROVAL STAMP. TCE SHALL BE DEEMED AS THE AUTHOR OF THESE DRAWINGS AND SHALL RETAIN ALL STATUTORY, COMMON LAWS, EDUCATION LAWS, AND ANY OTHER RESERVED RIGHTS INCLUDING COPYRIGHT. THE OWNER OF THE PREMISES SHALL BE ALLOWED TO RETAIN COPIES OF THE DRAWINGS, SPECIFICATIONS, AND OTHER DOCUMENTS FOR THIS PROJECT ONLY FOR THE WORK INDICATED ON THE DRAWINGS.

SEAL & SIGNATURE

AHJ STAMP

PROJECT NAME AND ADDRESS:

422 FULTON STREET
BROOKLYN, NY 11216

TITLE:


1ST FLOOR PLAN

FDNY RECORD ID #:

2022-EPPGFS-XXXXXX-PLAN


DATE:	07/13/2022
TCE JOB NUMBER:	TISHAYK02
DRAWING BY:	RAH
CHECK BY:	MMZ
TCE TEAM LEAD:	GIK
PROJECT MANAGER:	ATY
DRAWING NUMBER:	

NORTH ARROW

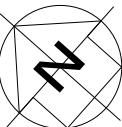


FL-1

SHEET:09OF 27

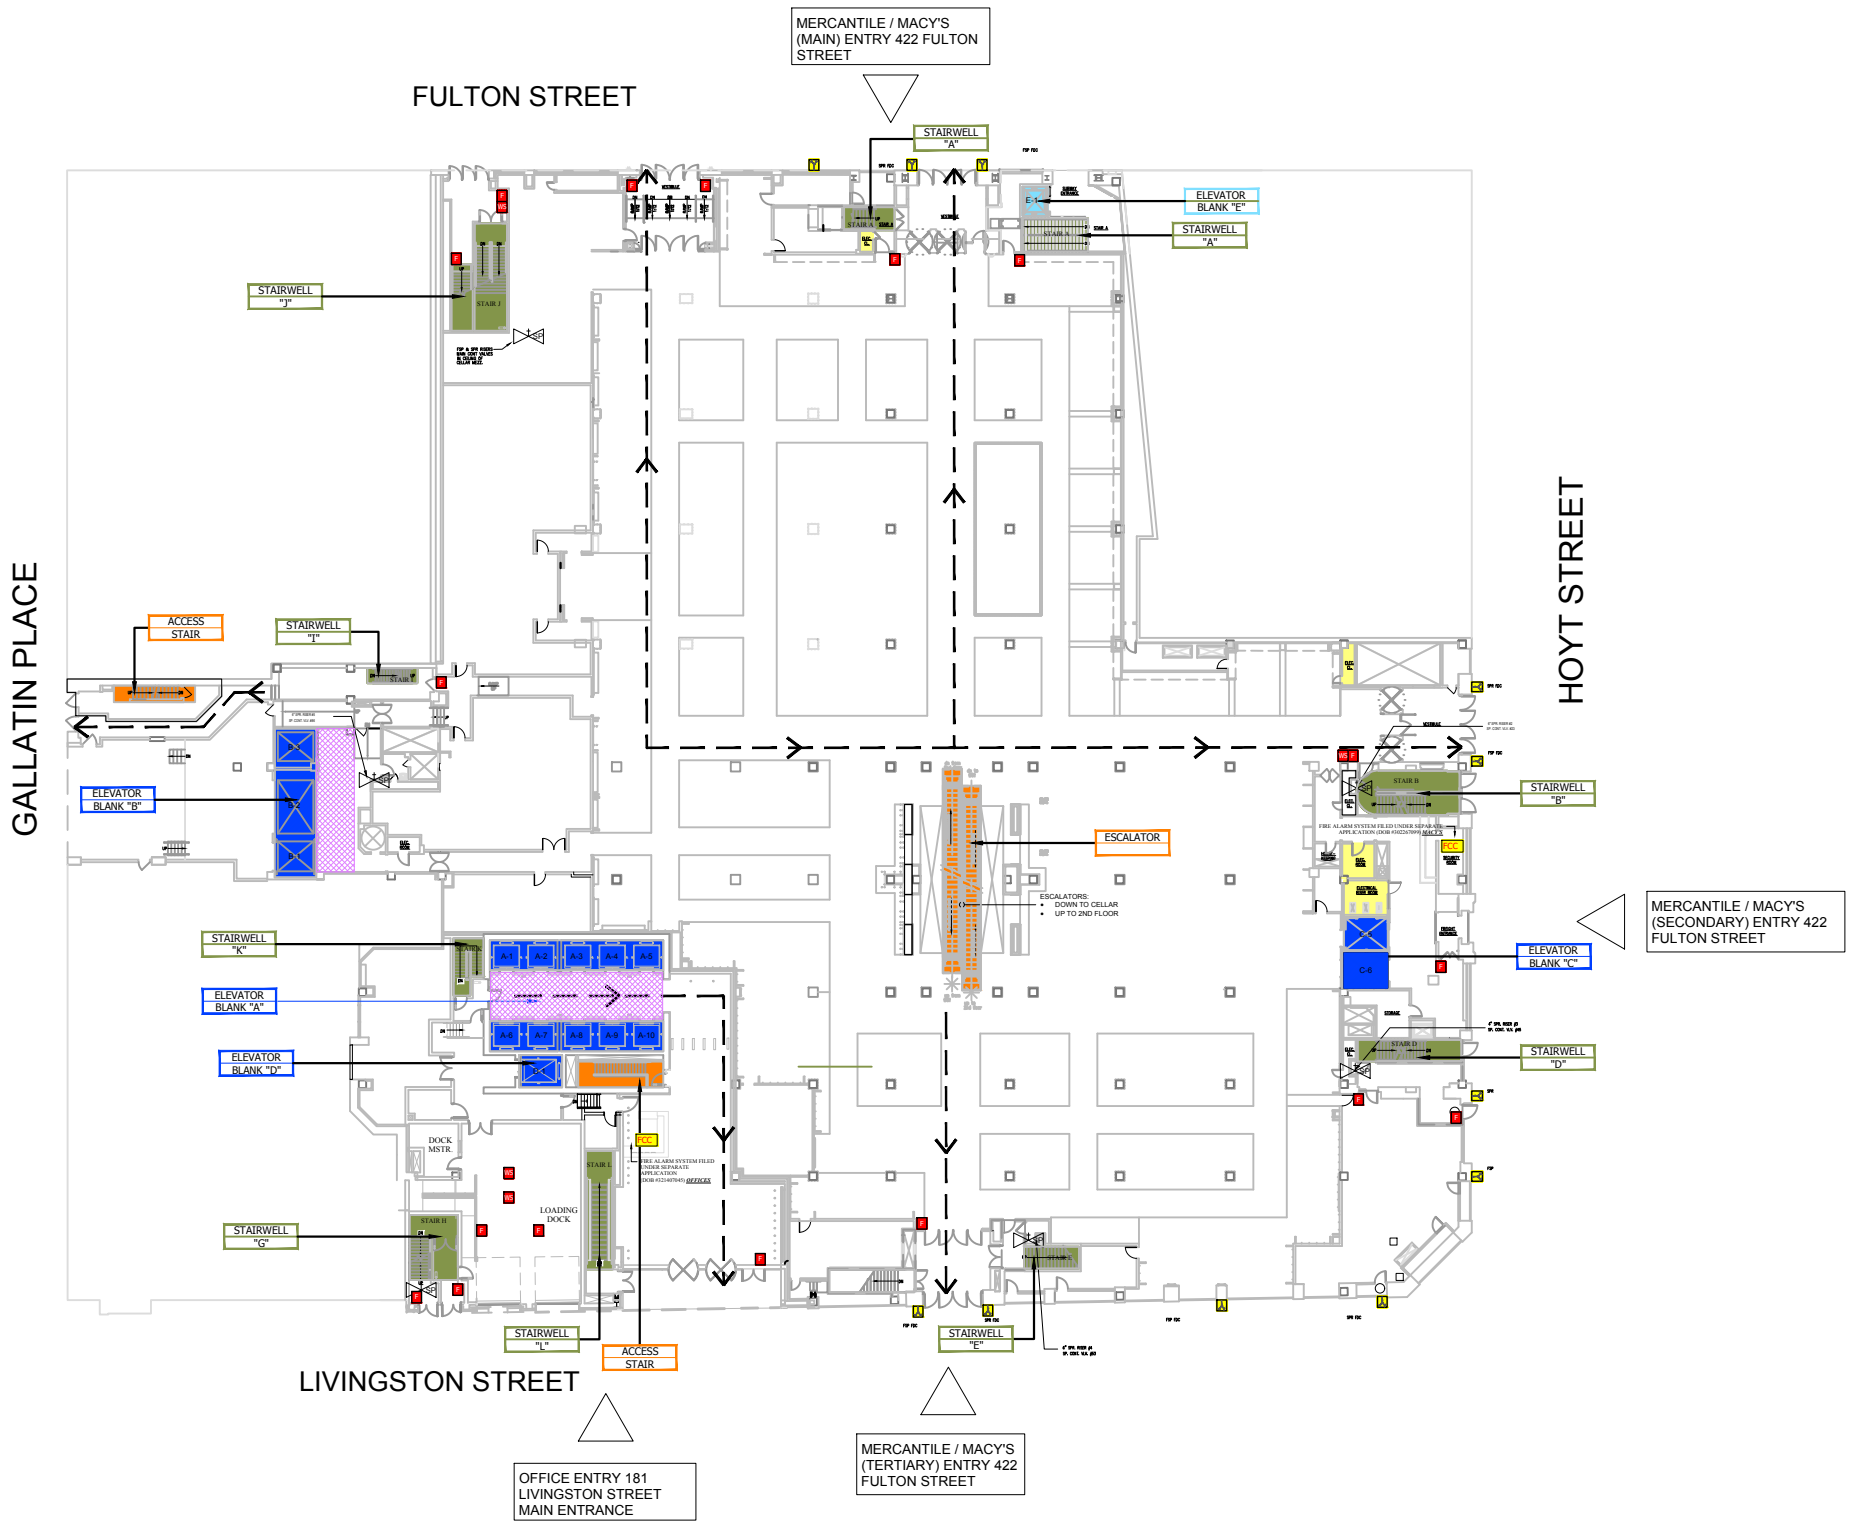

LEGEND:

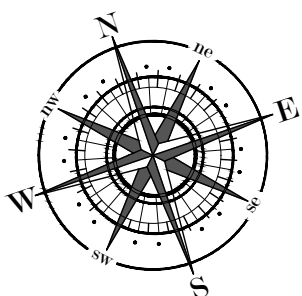 PULL STATION	 STANDPIPE/ SPRINKLER ISOLATION VALVE	 FDNY CONNECTION COMBINATION	 IN-BUILDING RELOCATION AREA	 MECHANICAL/ELECTRICAL SPACES (MER)	
 FIRE HOSE OUTLET	 SPRINKLER FLOOR CONTROL VALVE	 EVACUATION ROUTE	 ELEVATOR CAR & NUMBER DESIGNATION	 ELEVATOR BLIND SHAFT	
 WARDEN STATION	 SPRINKLER OS&Y SECTION VALVE	 CONCRETE WALL	 STAIRWELL	 NO ACCESS STAIRWELL	
 FIRE COMMAND STATION	 STANDPIPE ISOLATION VALVE		 CONVENIENCE/ ACCESS STAIRS		
 FIRE PUMP/ JOCKEY PUMP	 3 WAY MANIFOLD				



TOWER
CONSULTING ENGINEERS

120 West 31st Street - 7TH FLOOR
NEW YORK, N.Y. 10001
PHONE NO: (212) 444-8786
EMAIL: INFO@TOWERCE.COM
WWW.TOWERCE.COM

X	XX-XX-XXXX	XXXXXXXXXXXX
NO.	DATE	DETAILS

THESE DRAWINGS ARE THE PROPERTY OF TOWER CONSULTING ENGINEERS (TCE). THEY MAY NOT BE COPIED, REPRODUCED, ALTERED OR DISTRIBUTED WITHOUT WRITTEN CONSENT FROM TCE. THESE PLANS SHALL BE USED FOR ONLY THE WORK TYPE INDICATED ON THE DRAWINGS. LICENSED CONTRACTOR(S)/VENDOR(S) SHALL CONFIRM ALL FIELD CONDITIONS INCLUDING BUT NOT LIMITED TO LOCATION, DIMENSIONS, APPLICABLE CODES FROM ALL AUTHORITIES HAVING JURISDICTION (AHJ) AND LAWS ENACTED PRIOR TO INITIATING ANY WORK AND NOTIFY TCE OF ANY CONFLICTS, DISCREPANCIES, ERRORS, AND OMISSIONS WITNESSED IN WRITING. INSTALLATION OF ANY SCOPE INDICATED ON THE DRAWINGS SHALL NOT COMMENCE UNTIL THE AHJ APPROVES ANY AND ALL SCOPES SHOWN. THIS APPROVAL SHALL BE INDICATED ON THE PLANS VIA AN APPROVAL STAMP. TCE SHALL BE DEEMED AS THE AUTHOR OF THESE DRAWINGS AND SHALL RETAIN ALL STATUTORY, COMMON LAWS, EDUCATION LAWS, AND ANY OTHER RESERVED RIGHTS INCLUDING COPYRIGHT. THE OWNER OF THE PREMISES SHALL BE ALLOWED TO RETAIN COPIES OF THE DRAWINGS, SPECIFICATIONS, AND OTHER DOCUMENTS FOR THIS PROJECT ONLY FOR THE WORK INDICATED ON THE DRAWINGS.

SEAL & SIGNATURE

AHJ STAMP

PROJECT NAME AND ADDRESS :

422 FULTON STREET
BROOKLYN, NY 11216

TITLE :

1ST FLOOR MEZZ PLAN

FDNY RECORD ID #:

2022-EPPGFS-XXXXXX-PLAN


DATE: 07/13/2022
TCE JOB NUMBER: TISHAYK02
DRAWING BY: RAH
CHECK BY: MMZ
TCE TEAM LEAD: GIK
PROJECT MANAGER: ATY
DRAWING NUMBER:

NORTH ARROW



FL-2

SHEET:10OF 27

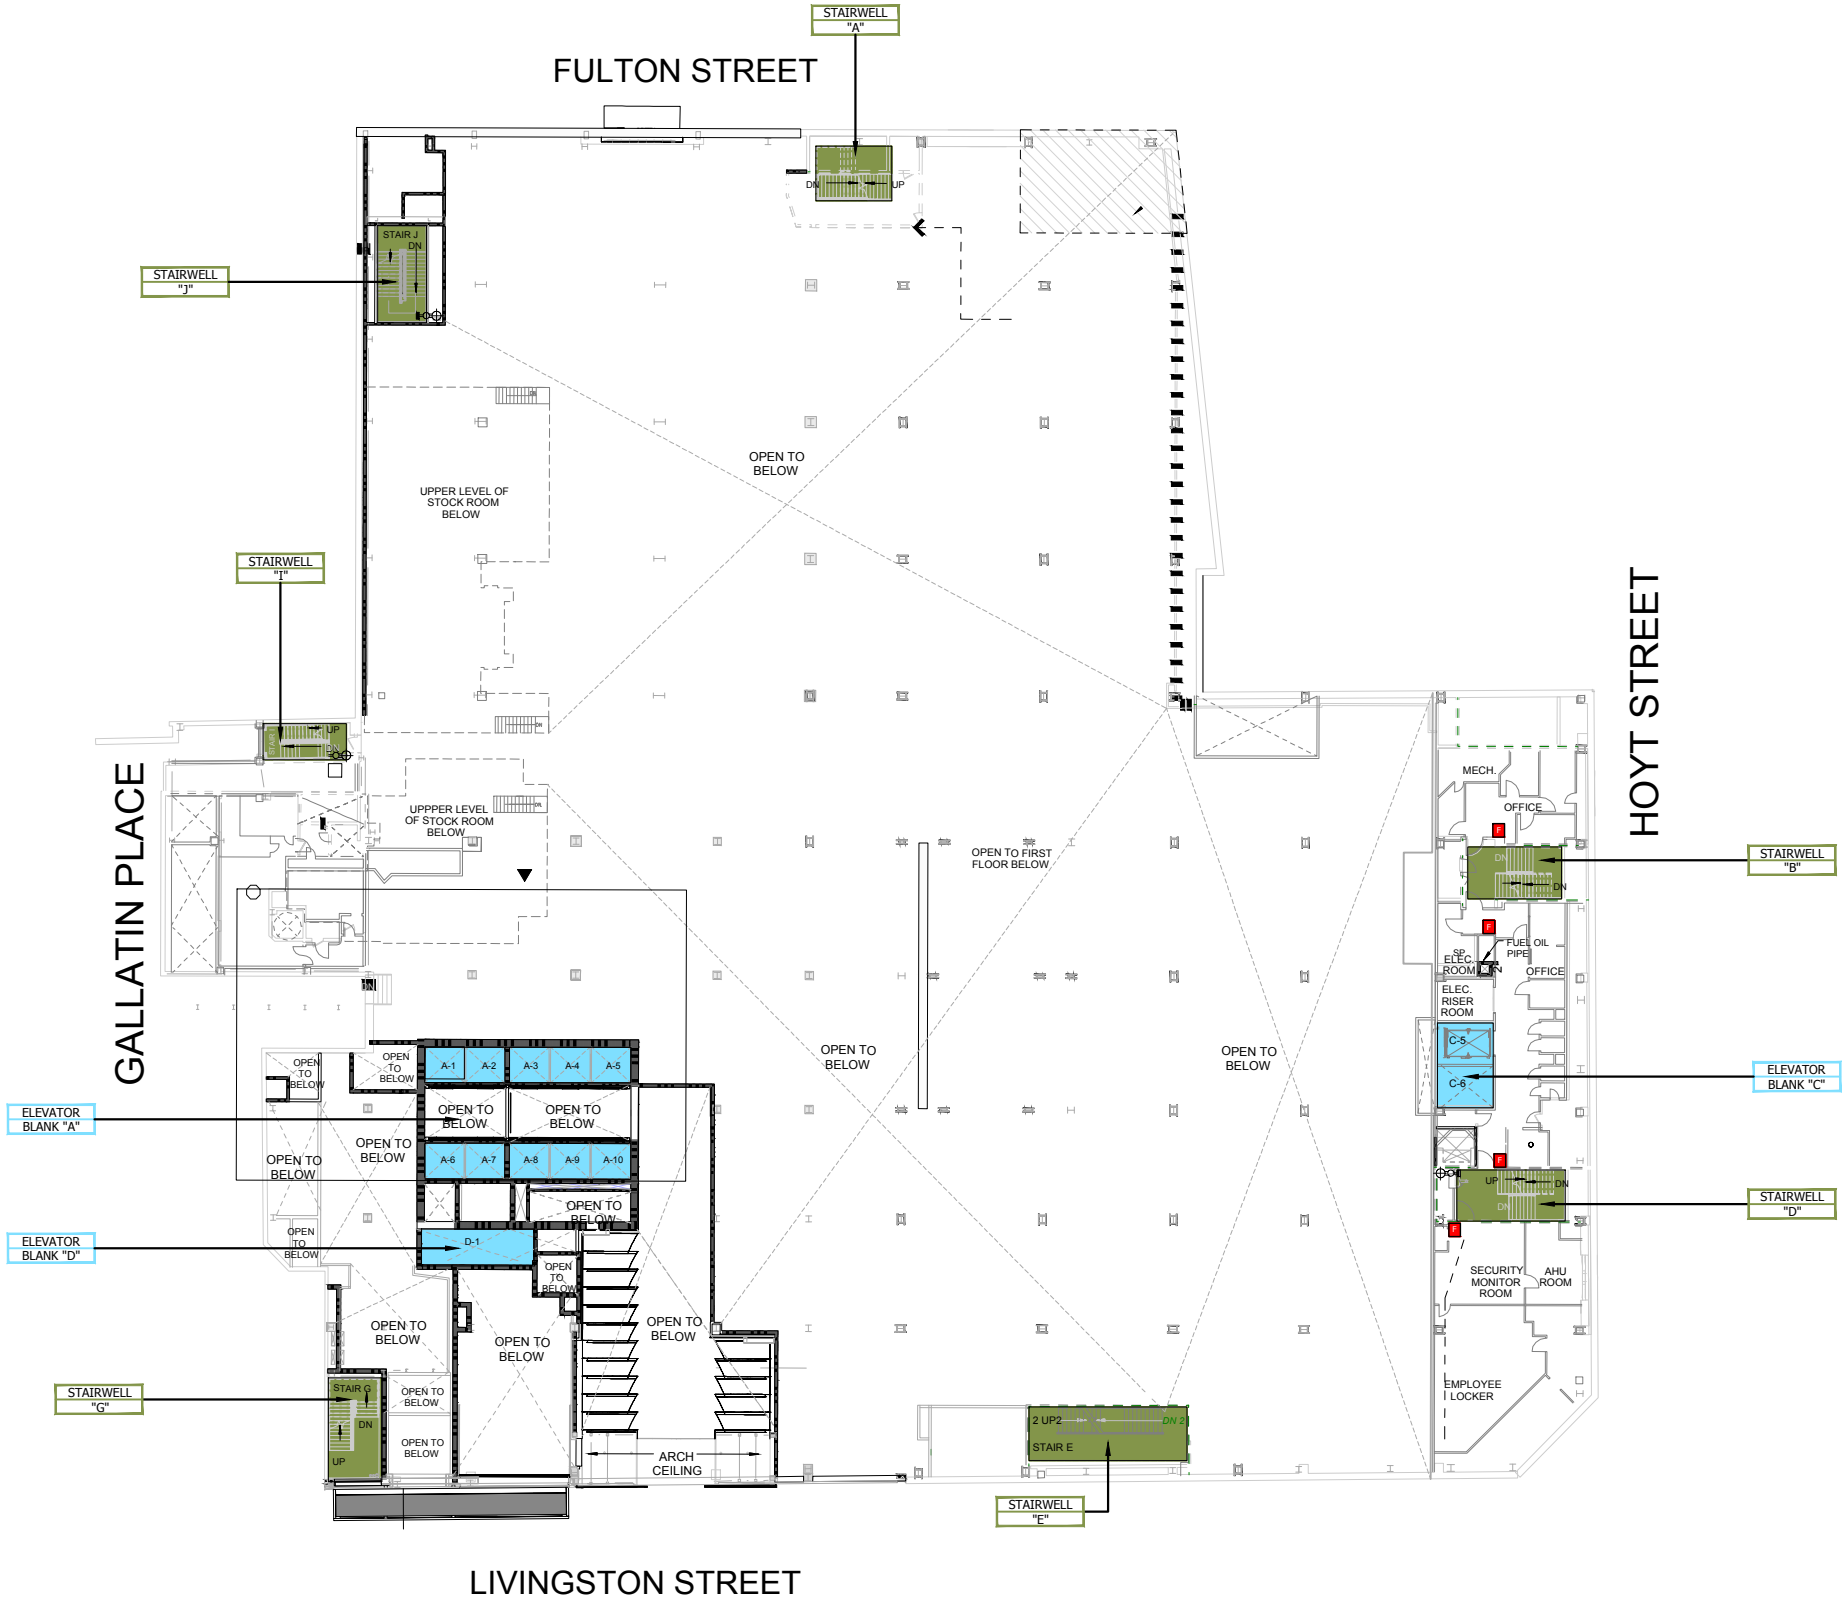

LEGEND:

PULL STATION	STANDPIPE/ SPRINKLER ISOLATION VALVE	FDNY CONNECTION COMBINATION	IN-BUILDING RELOCATION AREA	MECHANICAL/ELECTRICAL SPACES (MER)	
FIRE HOSE OUTLET	SPRINKLER FLOOR CONTROL VALVE	EVACUATION ROUTE	ELEVATOR CAR & NUMBER DESIGNATION	ELEVATOR BLIND SHAFT	
WARDEN STATION	SPRINKLER OS&Y SECTION VALVE	CONCRETE WALL	STAIRWELL	NO ACCESS STAIRWELL	
FIRE COMMAND STATION	STANDPIPE ISOLATION VALVE		CONVENIENCE/ ACCESS STAIRS		
FIRE PUMP/ JOCKEY PUMP	3 WAY MANIFOLD				



120 West 31st Street - 7TH FLOOR
NEW YORK, N.Y. 10001
PHONE NO: (212) 444-8786
EMAIL: INFO@TOWERCE.COM
WWW.TOWERCE.COM

X	XX-XX-XXXX	XXXXXXXXXXXXX
NO.	DATE	DETAILS

THESE DRAWINGS ARE THE PROPERTY OF TOWER CONSULTING ENGINEERS (TCE). THEY MAY NOT BE COPIED, REPRODUCED, ALTERED OR DISTRIBUTED WITHOUT WRITTEN CONSENT FROM TCE. THESE PLANS SHALL BE USED FOR ONLY THE WORK TYPE INDICATED ON THE DRAWINGS. LICENSED CONTRACTOR(S)/VENDOR(S) SHALL CONFIRM ALL FIELD CONDITIONS INCLUDING BUT NOT LIMITED TO LOCATION, DIMENSIONS, APPLICABLE CODES FROM ALL AUTHORITIES HAVING JURISDICTION (AHJ) AND LAWS ENACTED PRIOR TO INITIATING ANY WORK AND NOTIFY TCE OF ANY CONFLICTS, DISCREPANCIES, ERRORS, AND OMISSIONS WITNESSED IN WRITING. INSTALLATION OF ANY SCOPE INDICATED ON THE DRAWINGS SHALL NOT COMMENCE UNTIL THE AHJ APPROVES ANY AND ALL SCOPES SHOWN. THIS APPROVAL SHALL BE INDICATED ON THE PLANS VIA AN APPROVAL STAMP. TCE SHALL BE DEEMED AS THE AUTHOR OF THESE DRAWINGS AND SHALL RETAIN ALL STATUTORY, COMMON LAWS, EDUCATION LAWS, AND ANY OTHER RESERVED RIGHTS INCLUDING COPYRIGHT. THE OWNER OF THE PREMISES SHALL BE ALLOWED TO RETAIN COPIES OF THE DRAWINGS, SPECIFICATIONS, AND OTHER DOCUMENTS FOR THIS PROJECT ONLY FOR THE WORK INDICATED ON THE DRAWINGS.

SEAL & SIGNATURE

AHJ STAMP

PROJECT NAME AND ADDRESS :

422 FULTON STREET
BROOKLYN, NY 11216

TITLE :

2ND FLOOR PLAN

FDNY RECORD ID #:

2022-EPPGFS-XXXXXX-PLAN


DATE: 07/13/2022
TCE JOB NUMBER: TISHAYK02
DRAWING BY: RAH
CHECK BY: MMZ
TCE TEAM LEAD: GIK
PROJECT MANAGER: ATY
DRAWING NUMBER:

NORTH ARROW



FL-3

SHEET:11OF 27

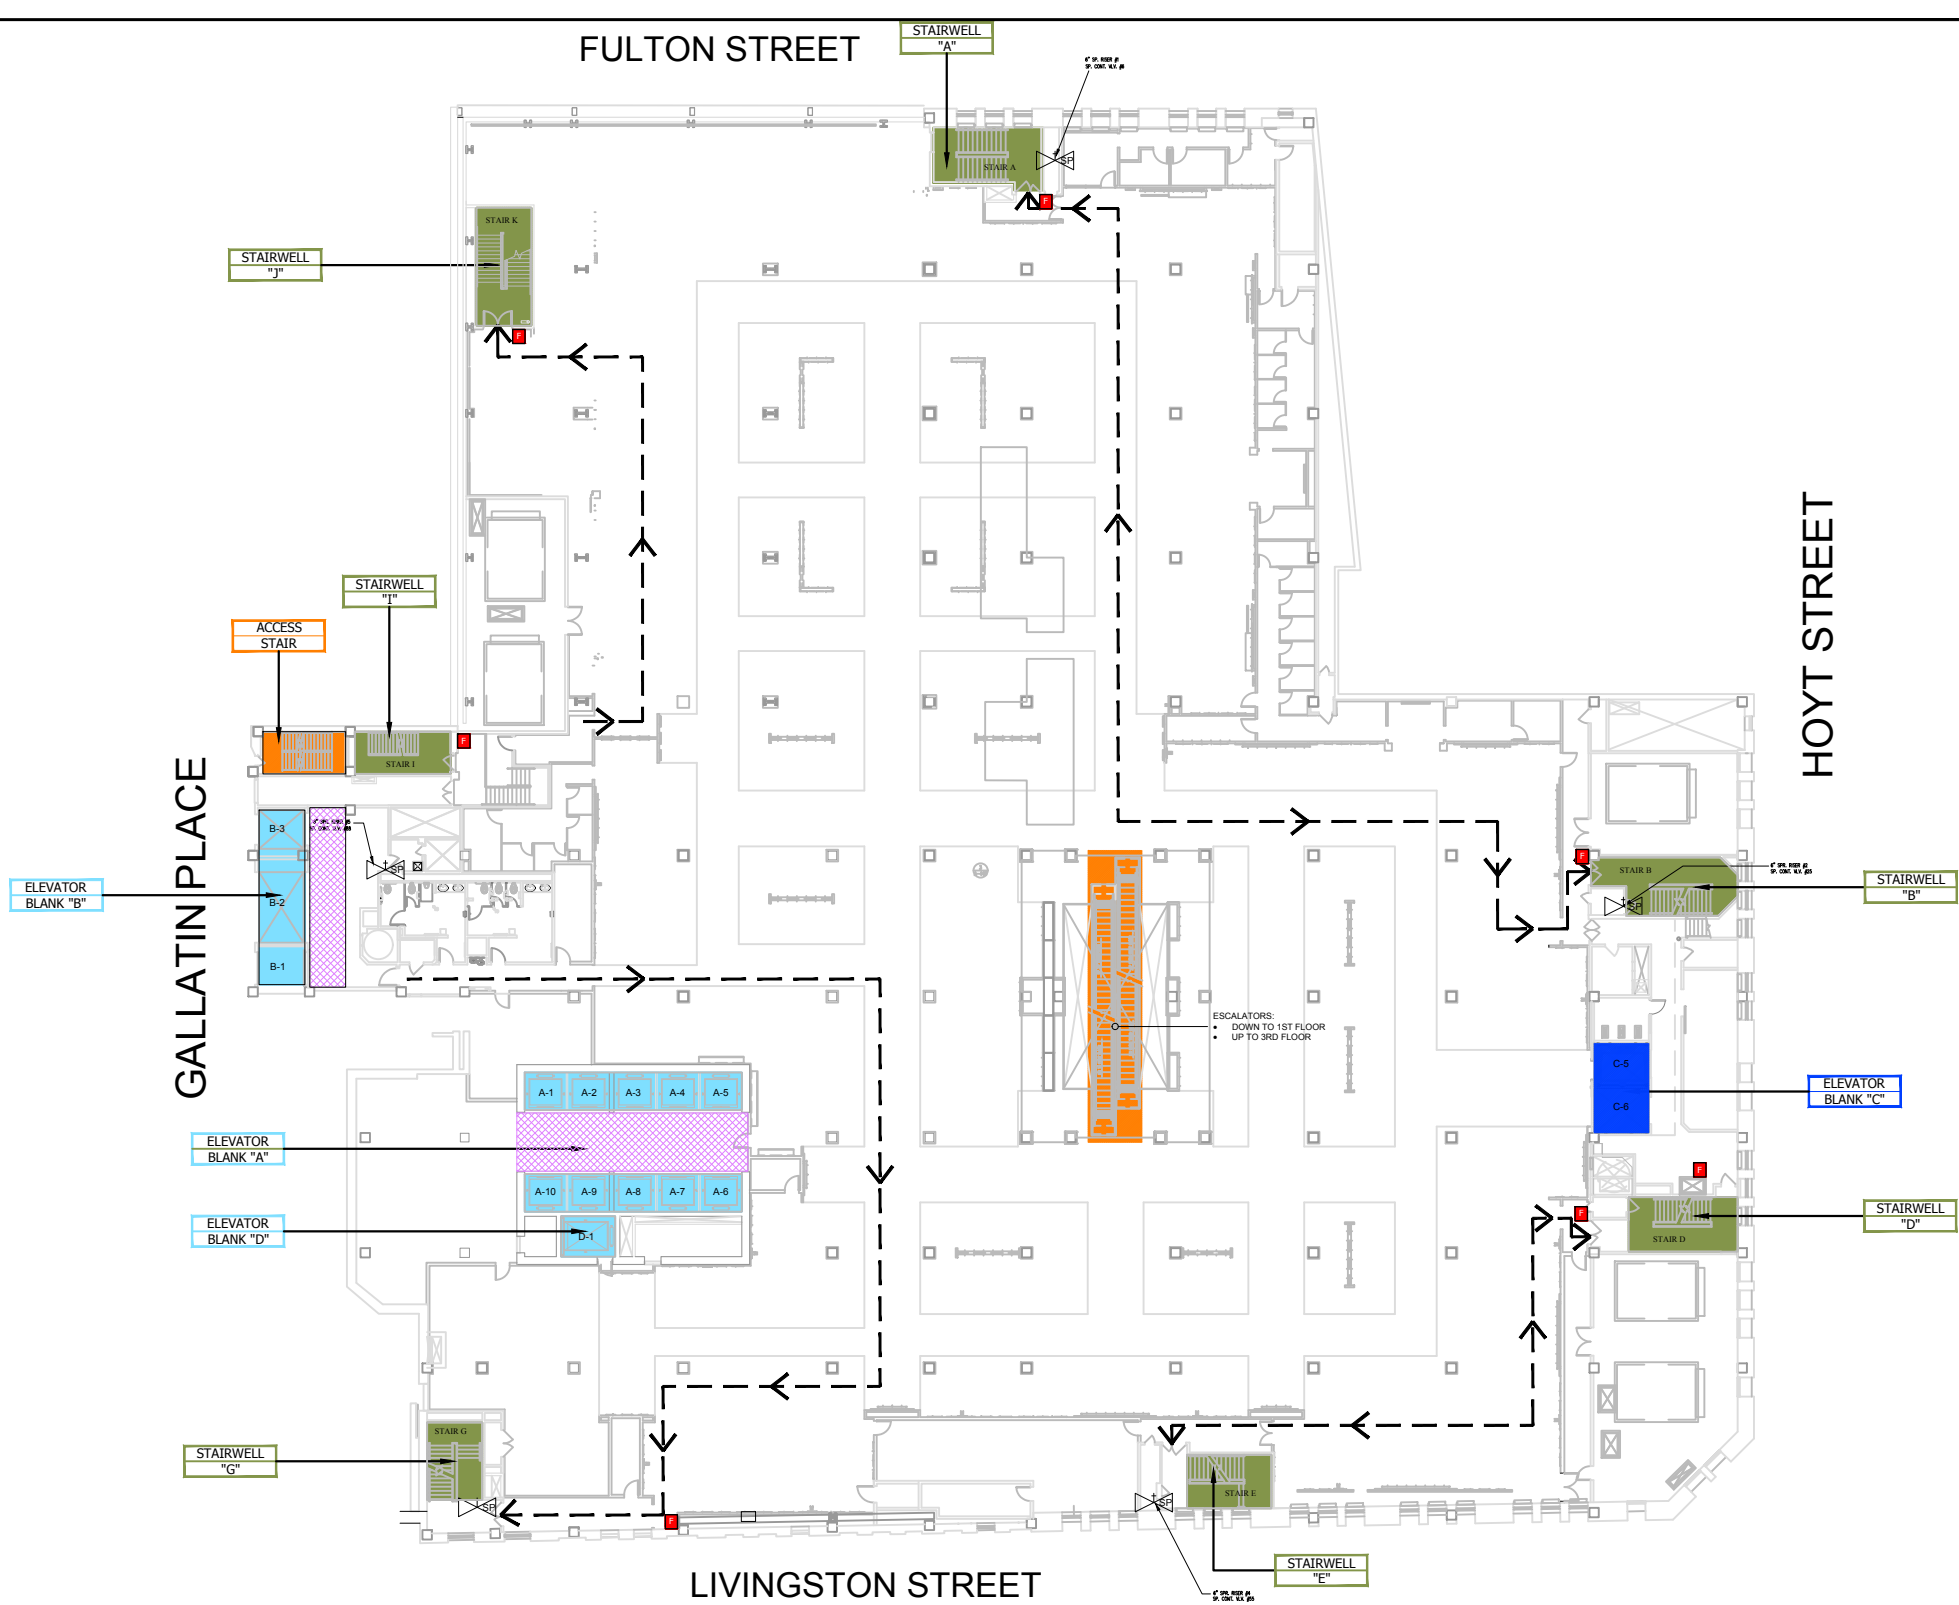

LEGEND:

PULL STATION	STANDPIPE/ SPRINKLER ISOLATION VALVE	FDNY CONNECTION COMBINATION	IN-BUILDING RELOCATION AREA	MECHANICAL/ELECTRICAL SPACES (MER)	
FIRE HOSE OUTLET	SPRINKLER FLOOR CONTROL VALVE	EVACUATION ROUTE	ELEVATOR CAR & NUMBER DESIGNATION	ELEVATOR BLIND SHAFT	
WARDEN STATION	SPRINKLER OS&Y SECTION VALVE	CONCRETE WALL	STAIRWELL	NO ACCESS STAIRWELL	
FIRE COMMAND STATION	STANDPIPE ISOLATION VALVE		CONVENIENCE/ ACCESS STAIRS		
FIRE PUMP/ JOCKEY PUMP	3 WAY MANIFOLD				



120 West 31st Street - 7TH FLOOR
NEW YORK, N.Y. 10001
PHONE NO: (212) 444-8786
EMAIL: INFO@TOWERCE.COM
WWW.TOWERCE.COM

X	XX-XX-XXXX	XXXXXXXXXXXXXX
NO.	DATE	DETAILS

THESE DRAWINGS ARE THE PROPERTY OF TOWER CONSULTING ENGINEERS (TCE). THEY MAY NOT BE COPIED, REPRODUCED, ALTERED OR DISTRIBUTED WITHOUT WRITTEN CONSENT FROM TCE. THESE PLANS SHALL BE USED FOR ONLY THE WORK TYPE INDICATED ON THE DRAWINGS. LICENSED CONTRACTOR(S)/VENDOR(S) SHALL CONFIRM ALL FIELD CONDITIONS INCLUDING BUT NOT LIMITED TO LOCATION, DIMENSIONS, APPLICABLE CODES FROM ALL AUTHORITIES HAVING JURISDICTION (AHJ) AND LAWS ENACTED PRIOR TO INITIATING ANY WORK AND NOTIFY TCE OF ANY DISCREPANCIES, DISCREPANCIES, OMISSIONS AND VIOLATIONS IN WRITING. INSTALLATION OF ANY SCOPE INDICATED ON THE DRAWINGS SHALL NOT COMMENCE UNTIL THE AHJ APPROVES ANY AND ALL SCOPES SHOWN. THIS APPROVAL SHALL BE INDICATED ON THE PLANS VIA AN APPROVAL STAMP. TCE SHALL BE DEEMED AS THE AUTHOR OF THESE DRAWINGS AND SHALL RETAIN ALL STATUTORY, COMMON LAWS, EDUCATION LAWS, AND ANY OTHER RESERVED RIGHTS INCLUDING BUT NOT LIMITED TO THE RIGHT TO OBTAIN AND RETAIN COPIES OF THE DRAWINGS, SPECIFICATIONS, AND OTHER DOCUMENTS FOR THIS PROJECT ONLY FOR THE WORK INDICATED ON THE DRAWINGS.

SEAL & SIGNATURE

AHJ STAMP

PROJECT NAME AND ADDRESS :

422 FULTON STREET
BROOKLYN, NY 11216

TITLE :

3RD FLOOR PLAN

FDNY RECORD ID #:

2022-EPPGFS-XXXXXX-PLAN

DATE: 07/13/2022

TCE JOB NUMBER: TISHAYK02

DRAWING BY: RAH


CHECK BY: MMZ

TCE TEAM LEAD:	GIK
----------------	-----

PROJECT MANAGER:	ATY
------------------	-----

DRAWING NUMBER:

NORTH ARROW

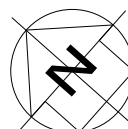


FL-4

SHEET:12 OF 27



 LEGEND:

 PULL STATION	 STANDPIPE/ SPRINKLER ISOLATION VALVE	 FDNY CONNECTION COMBINATION	 IN-BUILDING RELOCATION AREA  ELEVATOR CAR & NUMBER DESIGNATION  STAIRWELL  CONVENIENCE/ ACCESS STAIRS  MECHANICAL/ELECTRICAL SPACES (MER)  ELEVATOR BLIND SHAFT  NO ACCESS STAIRWELL	
 FIRE HOSE OUTLET	 SPRINKLER FLOOR CONTROL VALVE	 EVACUATION ROUTE		
 WARDEN STATION	 SPRINKLER OS&Y SECTION VALVE	 CONCRETE WALL		
 FIRE COMMAND STATION	 STANDPIPE ISOLATION VALVE			
 FIRE PUMP/ JOCKEY PUMP	 3 WAY MANIFOLD			



120 West 31st Street - 7TH FLOOR
NEW YORK, N.Y. 10001
PHONE NO: (212) 444-8786
EMAIL: INFO@TOWERCE.COM
WWW.TOWERCE.COM

X	XX-XX-XXXX	XXXXXXXXXXXXXX
NO.	DATE	DETAILS

THESE DRAWINGS ARE THE PROPERTY OF TOWER CONSULTING ENGINEERS (TCE). THEY MAY NOT BE COPIED, REPRODUCED, ALTERED OR DISTRIBUTED WITHOUT WRITTEN CONSENT FROM TCE. THESE PLANS SHALL BE USED FOR ONLY THE WORK TYPE INDICATED ON THE DRAWINGS. LICENSED CONTRACTOR(S)/VENDOR(S) SHALL CONFIRM ALL FIELD CONDITIONS INCLUDING BUT NOT LIMITED TO LOCATION, DIMENSIONS, APPLICABLE CODES AND ALL APPLICABLE ORDINANCES, RULES AND LAWS ENACTED PRIOR TO INITIATING ANY WORK AND NOTIFY TCE OF ANY CONFLICTS, DISCREPANCIES, ERRORS, AND OMISSIONS WITNESSED IN WRITING. INSTALLATION OF ANY SCOPE INDICATED ON THE DRAWINGS SHALL NOT COMMENCE UNTIL THE AHI APPROVES ANY AND ALL SCOPES SHOWN. THIS APPROVAL SHALL BE INDICATED ON THE PLANS VIA AN APPROVAL STAMP. TCE SHALL BE DEEMED AS THE AUTHOR OF THESE DRAWINGS AND SHALL RETAIN ALL STATUTORY, COMMON LAW, AND EDUCATION LAWS AND OTHER RELATED RIGHTS INCLUDING COPYRIGHT. THE OWNER OF THE PREMISES SHALL BE ALLOWED TO RETAIN COPIES OF THE DRAWINGS, SPECIFICATIONS, AND OTHER DOCUMENTS FOR THIS PROJECT ONLY FOR THE WORK INDICATED ON THE DRAWINGS.

SEAL & SIGNATURE

AHJ STAMP

PROJECT NAME AND ADDRESS :

422 FULTON STREET
BROOKLYN, NY 11216

TITLE :

4TH FLOOR PLAN

FDNY RECORD ID #:

2022-EPPGFS-XXXXXX-PLAN

DATE: 07/13/2022

TCE JOB NUMBER: TISHAYK00

DRAWING BY: RAH


CHECK BY: _____ MM: _____

TCE TEAM LEAD: GIK

PROJECT MANAGER: ATY


DRAWING NUMBER:

NORTH ARROW

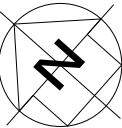

FL-5

SHEET:13 OF 27

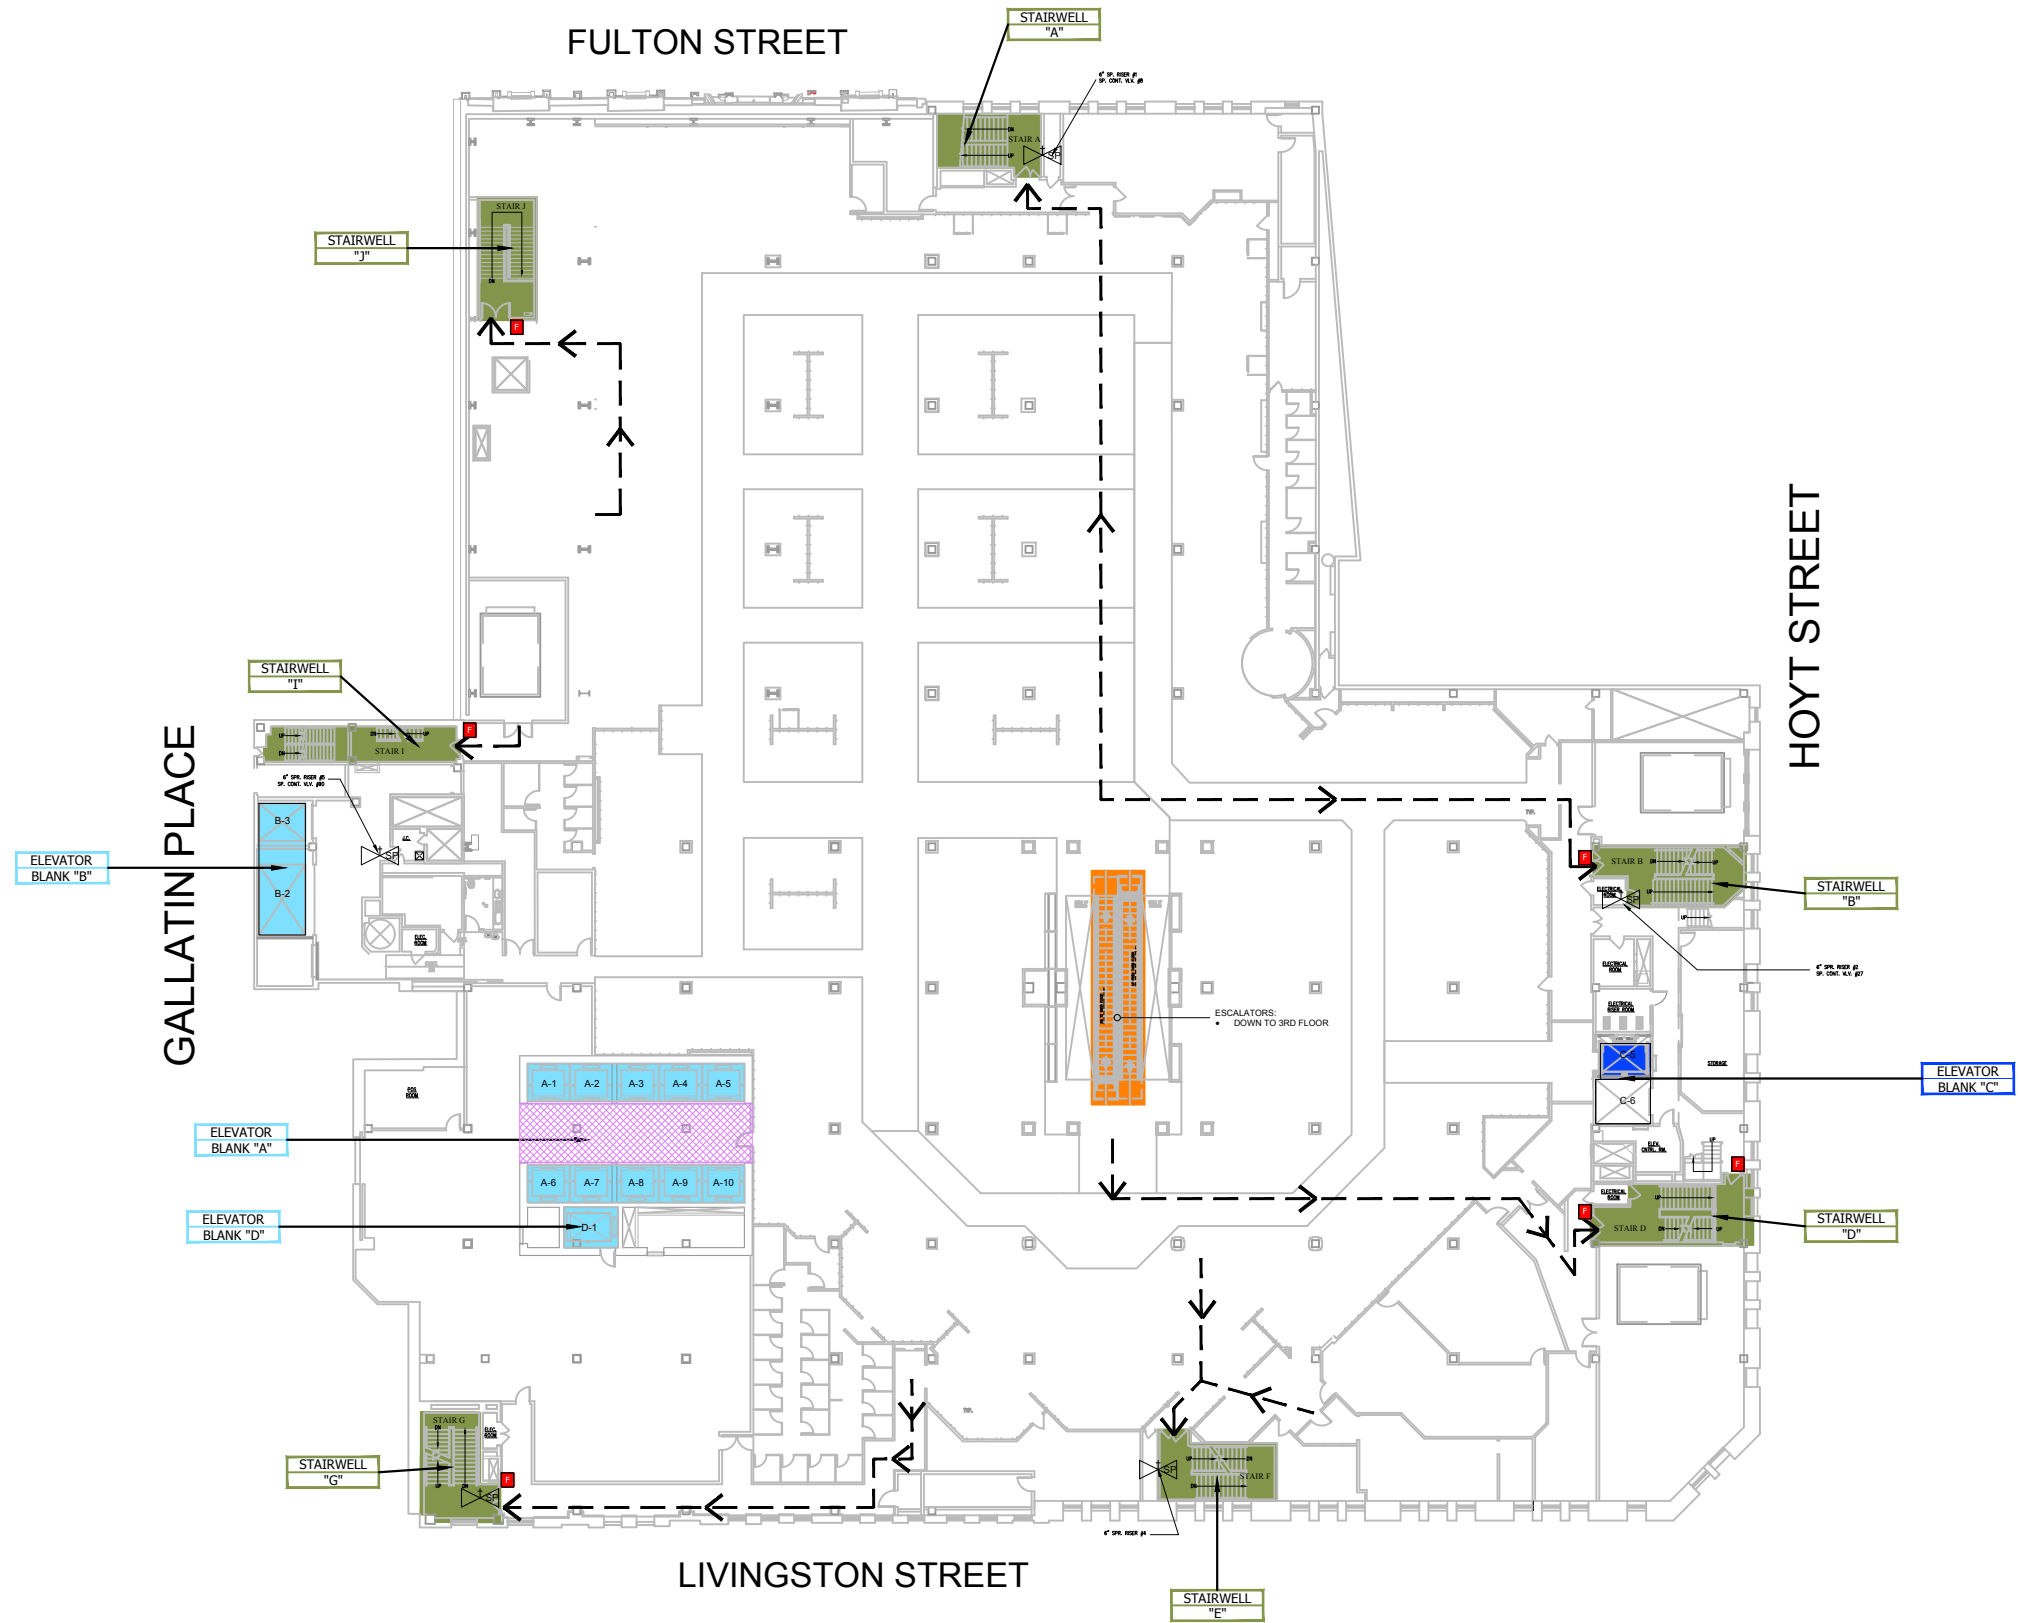

LEGEND:

 PULL STATION	 STANDPIPE/ SPRINKLER ISOLATION VALVE	 FDNY CONNECTION COMBINATION	 IN-BUILDING RELOCATION AREA  ELEVATOR CAR & NUMBER DESIGNATION  STAIRWELL  CONVENIENCE/ ACCESS STAIRS  MECHANICAL/ELECTRICAL SPACES (MER)  ELEVATOR BLIND SHAFT  NO ACCESS STAIRWELL	
 FIRE HOSE OUTLET	 SPRINKLER FLOOR CONTROL VALVE	 EVACUATION ROUTE		
 WARDEN STATION	 SPRINKLER OS&Y SECTION VALVE	 CONCRETE WALL		
 FIRE COMMAND STATION	 STANDPIPE ISOLATION VALVE			
 FIRE PUMP/ JOCKEY PUMP	 3 WAY MANIFOLD			



120 West 31st Street - 7TH FLOOR
NEW YORK, N.Y. 10001
PHONE NO: (212) 444-8786
EMAIL: INFO@TOWERCE.COM
WWW.TOWERCE.COM

X	XX-XX-XXXX	XXXXXXXXXXXXXX
NO.	DATE	DETAILS

THESE DRAWINGS ARE THE PROPERTY OF TOWER CONSULTING ENGINEERS (TCE). THEY MAY NOT BE COPIED, REPRODUCED, ALTERED OR DISTRIBUTED WITHOUT WRITTEN CONSENT FROM TCE. THESE PLANS SHALL BE USED FOR ONLY THE WORK TYPE INDICATED ON THE DRAWINGS. LICENSED CONTRACTOR(S)/VENDOR(S) SHALL CONFIRM ALL FIELD CONDITIONS INCLUDING BUT NOT LIMITED TO LOCATION, DIMENSIONS, APPLICABLE CODES FROM ALL AUTHORITIES HAVING JURISDICTION (AHJ) AND LAWS ENACTED PRIOR TO INITIATING ANY WORK AND NOTIFY TCE OF ANY CONFLICTS OR DISCREPANCIES. ANY CHANGES MUST BE APPROVED IN WRITING. INSTALLATION OF ANY SCOPE INDICATED ON THE DRAWINGS SHALL NOT COMMENCE UNTIL THE AHJ APPROVES ANY AND ALL SCOPES SHOWN. THIS APPROVAL SHALL BE INDICATED ON THE PLANS VIA AN APPROVAL STAMP. TCE SHALL BE DEEMED AS THE AUTHOR OF THESE DRAWINGS AND SHALL RETAIN ALL STATUTORY, COMMON LAWS, EDUCATION LAWS, AND ANY OTHER RESERVED RIGHTS INCLUDING BUT NOT LIMITED TO THE OWNERSHIP OF THE DRAWINGS AND TO RETAIN COPIES OF THE DRAWINGS, SPECIFICATIONS, AND OTHER DOCUMENTS FOR THIS PROJECT ONLY FOR THE WORK INDICATED ON THE DRAWINGS.

SEAL & SIGNATURE

AHJ STAMP

PROJECT NAME AND ADDRESS :

422 FULTON STREET
BROOKLYN, NY 11216

TITLE :


5TH FLOOR PLAN

FDNY RECORD ID #:

2022-EPPGFS-XXXXXX-PLAN

DATE:	07/13/2022
TCE JOB NUMBER:	TISHAYK0
DRAWING BY:	RAH
CHECK BY:	MM
TCE TEAM LEAD:	GIR
PROJECT MANAGER:	ATY
DRAWING NUMBER:	

NORTH ARROW

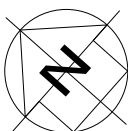

FL-6

SHEET:14 OF 27



LEGEND:

 PULL STATION	 STANDPIPE/ SPRINKLER ISOLATION VALVE	 FDNY CONNECTION COMBINATION	 IN-BUILDING RELOCATION AREA  ELEVATOR CAR & NUMBER DESIGNATION  STAIRWELL  CONVENIENCE/ ACCESS STAIRS  MECHANICAL/ELECTRICAL SPACES (MER)  ELEVATOR BLIND SHAFT  NO ACCESS STAIRWELL	
 FIRE HOSE OUTLET	 SPRINKLER FLOOR CONTROL VALVE	 EVACUATION ROUTE		
 WARDEN STATION	 SPRINKLER OS&Y SECTION VALVE	 CONCRETE WALL		
 FIRE COMMAND STATION	 STANDPIPE ISOLATION VALVE			
 FIRE PUMP/ JOCKEY PUMP	 3 WAY MANIFOLD			



120 West 31st Street - 7TH FLOOR
NEW YORK, N.Y. 10001
PHONE NO: (212) 444-8786
EMAIL: INFO@TOWERCE.COM
WWW.TOWERCE.COM

X	XX-XX-XXXX	XXXXXXXXXXXX
NO.	DATE	DETAILS

THESE DRAWINGS ARE THE PROPERTY OF TOWER CONSULTING ENGINEERS (TCE). THEY MAY NOT BE COPIED, REPRODUCED, ALTERED OR DISTRIBUTED WITHOUT WRITTEN CONSENT FROM TCE. THESE PLANS SHALL BE USED FOR ONLY THE WORK TYPE INDICATED ON THE DRAWINGS. LICENSED CONTRACTOR(S)/VENDOR(S) SHALL CONFIRM ALL FIELD CONDITIONS INCLUDING BUT NOT LIMITED TO LOCATION, DIMENSIONS, APPLICABLE CODES AND ALL APPLICABLE ORDINANCES, REGULATIONS AND LAWS ENACTED PRIOR TO INITIATING ANY WORK AND NOTIFY TCE OF ANY CONFLICTS, DISCREPANCIES, ERRORS, AND OMISSIONS WITNESSED IN WRITING. INSTALLATION OF ANY SCOPE INDICATED ON THE DRAWINGS SHALL NOT COMMENCE UNTIL THE A/E APPROVES ANY AND ALL SCOPES SHOWN. THIS APPROVAL SHALL BE INDICATED ON THE PLANS VIA AN APPROVAL STAMP. TCE SHALL BE DEEMED AS THE AUTHOR OF THESE DRAWINGS AND SHALL RETAIN ALL STATUTORY, COMMON LAW, AND EDUCATION LAWS AND OTHER RELATED RIGHTS INCLUDING COPYRIGHT. THE OWNER OF THE PREMISES SHALL BE ALLOWED TO RETAIN COPIES OF THE DRAWINGS, SPECIFICATIONS, AND OTHER DOCUMENTS FOR THIS PROJECT ONLY FOR THE WORK INDICATED ON THE DRAWINGS.

SEAL & SIGNATURE

AHJ STAMP

PROJECT NAME AND ADDRESS :

422 FULTON STREET
BROOKLYN, NY 11216

TITLE:


6TH FLOOR PLAN

FDNY RECORD ID #:

2022-EPPGFS-XXXXXX-PLAN


DATE:	07/13/2022
TCE JOB NUMBER:	TISHAYK02
DRAWING BY:	RAH
CHECK BY:	MMZ
TCE TEAM LEAD:	GIK
PROJECT MANAGER:	ATY
DRAWING NUMBER:	

NORTH ARROW

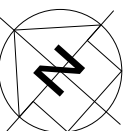


FL-7

SHEET:15 OF 27

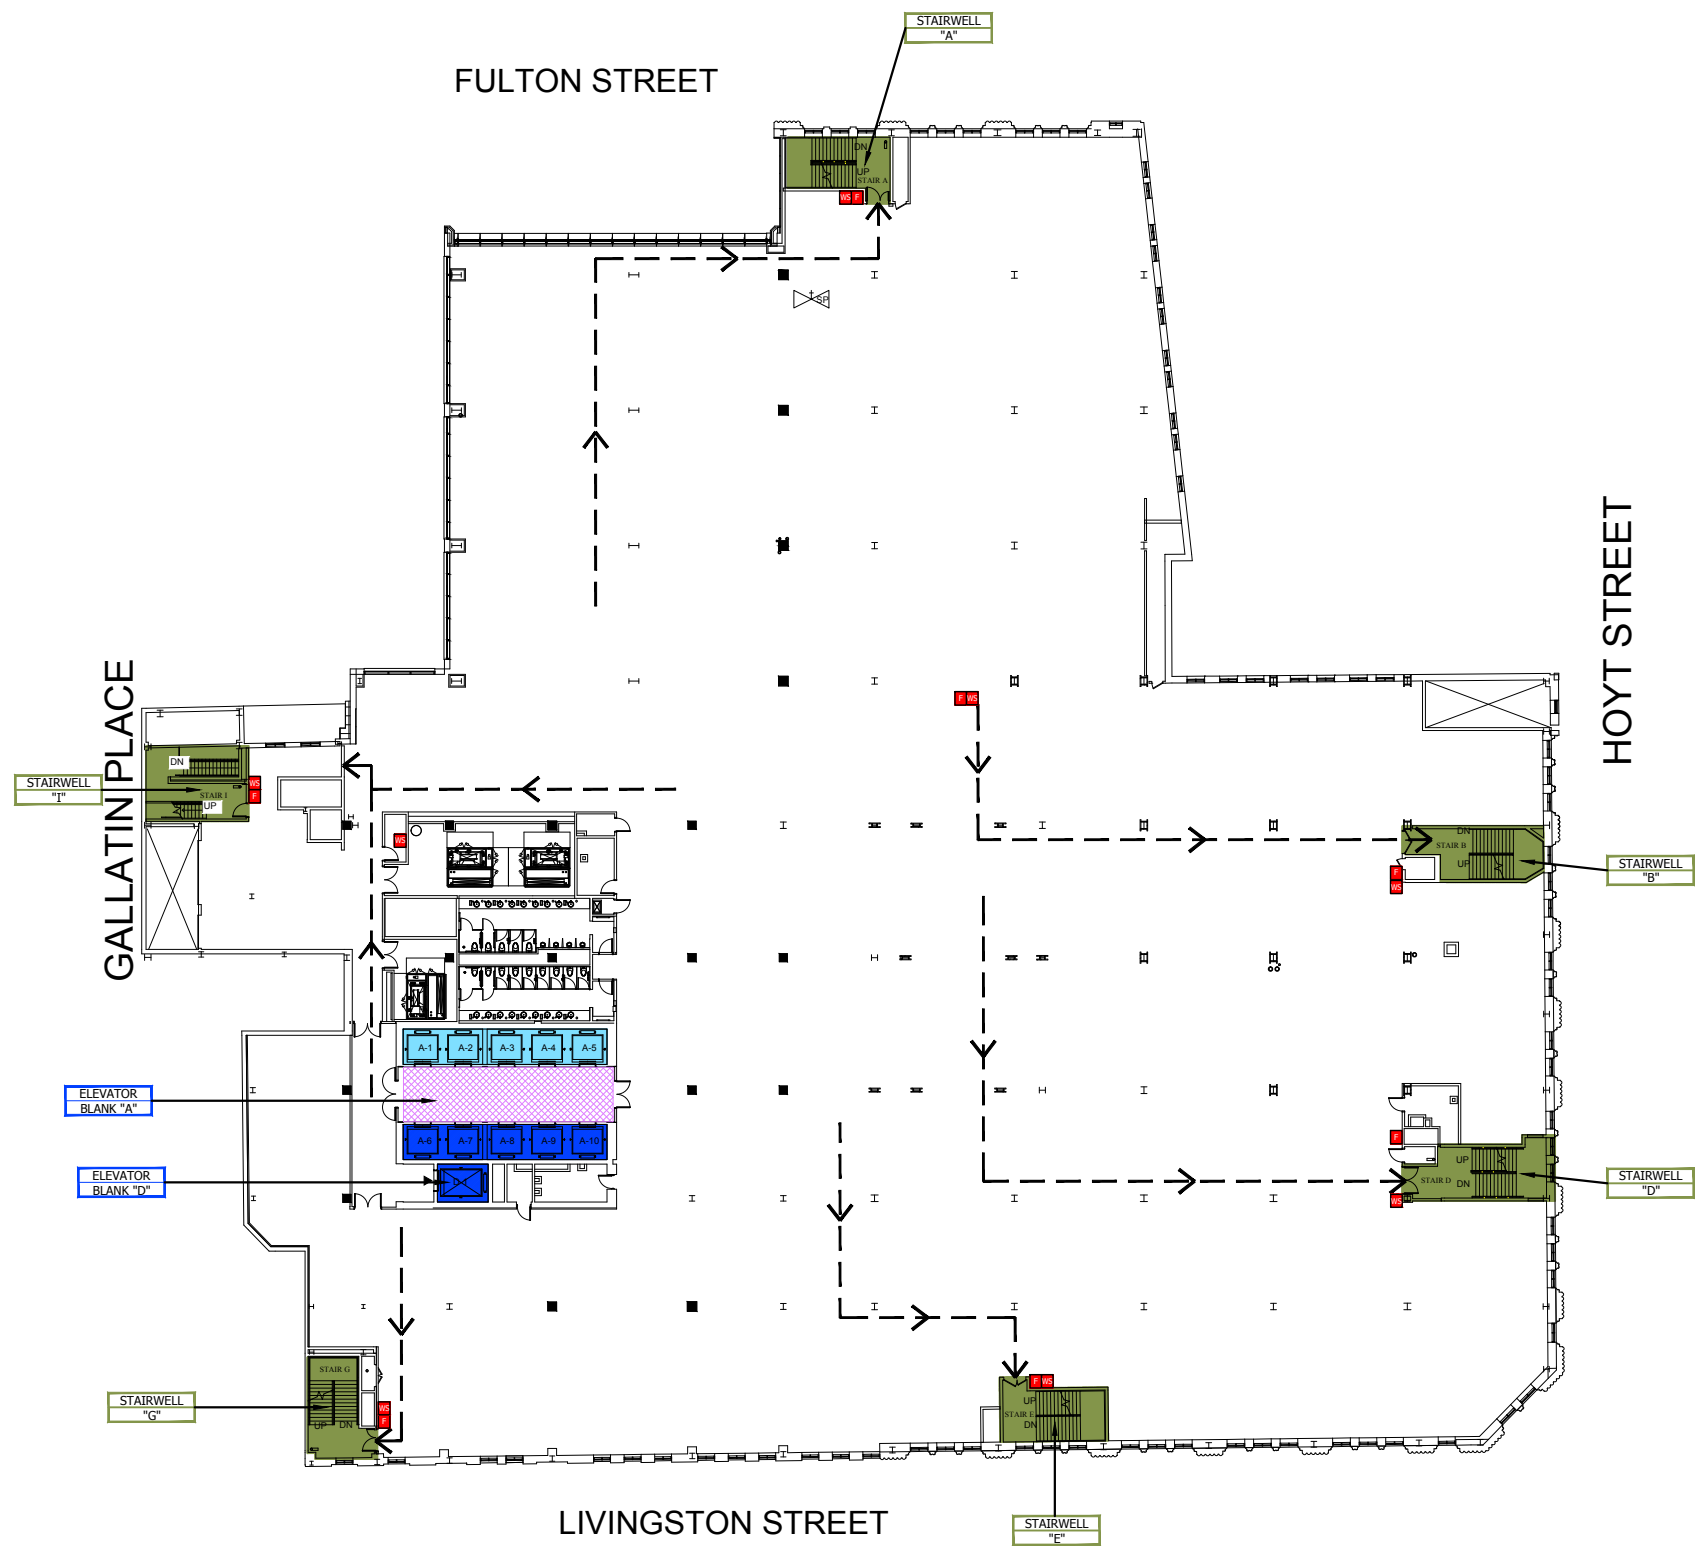

LEGEND:

  PULL STATION	 STANDPIPE/ SPRINKLER ISOLATION VALVE	 FDNY CONNECTION COMBINATION	 IN-BUILDING RELOCATION AREA  ELEVATOR CAR & NUMBER DESIGNATION  STAIRWELL  CONVENIENCE/ ACCESS STAIRS  MECHANICAL/ELECTRICAL SPACES (MER)  ELEVATOR BLIND SHAFT  NO ACCESS STAIRWELL	
 FIRE HOSE OUTLET	 SPRINKLER FLOOR CONTROL VALVE	 EVACUATION ROUTE		
 WARDEN STATION	 SPRINKLER OS&Y SECTION VALVE	 CONCRETE WALL		
 FIRE COMMAND STATION	 STANDPIPE ISOLATION VALVE			
 FIRE PUMP/ JOCKEY PUMP	 3 WAY MANIFOLD			



120 West 31st Street - 7TH FLOOR
NEW YORK, N.Y. 10001
PHONE NO: (212) 444-8786
EMAIL: INFO@TOWERCE.COM
WWW.TOWERCE.COM

X	XX-XX-XXXX	XXXXXXXXXXXXXX
NO.	DATE	DETAILS

THESE DRAWINGS ARE THE PROPERTY OF TOWER CONSULTING ENGINEERS (TCE). THEY MAY NOT BE COPIED, REPRODUCED, ALTERED OR DISTRIBUTED WITHOUT WRITTEN CONSENT FROM TCE. THESE PLANS SHALL BE USED FOR ONLY THE WORK TYPE INDICATED ON THE DRAWINGS. LICENSED CONTRACTOR(S)/VENDOR(S) SHALL CONFIRM ALL FIELD CONDITIONS INCLUDING BUT NOT LIMITED TO LOCATION, DIMENSIONS, APPLICABLE CODES FROM ALL AUTHORITIES HAVING JURISDICTION (AHJ) AND LAWS ENACTED PRIOR TO INITIATING ANY WORK AND NOTIFY TCE OF ANY CONFLICTS OR DISCREPANCIES. ANY CHANGES MUST BE APPROVED IN WRITING. INSTALLATION OF ANY SCOPE INDICATED ON THE DRAWINGS SHALL NOT COMMENCE UNTIL THE AHJ APPROVES ANY AND ALL SCOPES SHOWN. THIS APPROVAL SHALL BE INDICATED ON THE PLANS VIA AN APPROVAL STAMP. TCE SHALL BE DEEMED AS THE AUTHOR OF THESE DRAWINGS AND SHALL RETAIN ALL STATUTORY, COMMON LAWS, EDUCATION LAWS, AND ANY OTHER RESERVED RIGHTS INCLUDING BUT NOT LIMITED TO THE OWNERSHIP OF THE DRAWINGS AND TO RETAIN COPIES OF THE DRAWINGS, SPECIFICATIONS, AND OTHER DOCUMENTS FOR THIS PROJECT ONLY FOR THE WORK INDICATED ON THE DRAWINGS.

SEAL & SIGNATURE

AHJ STAMP

PROJECT NAME AND ADDRESS :

422 FULTON STREET
BROOKLYN, NY 11216

TITLE :


7TH FLOOR PLAN

FDNY RECORD ID #:

2022-EPPGFS-XXXXXX-PLAN


DATE:	07/13/2022
TCE JOB NUMBER:	TISHAYK02
DRAWING BY:	RAH
CHECK BY:	MM2
TCE TEAM LEAD:	GIK
PROJECT MANAGER:	ATY
DRAWING NUMBER:	

NORTH ARROW

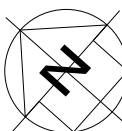

FL-8

SHEET:16 OF 27

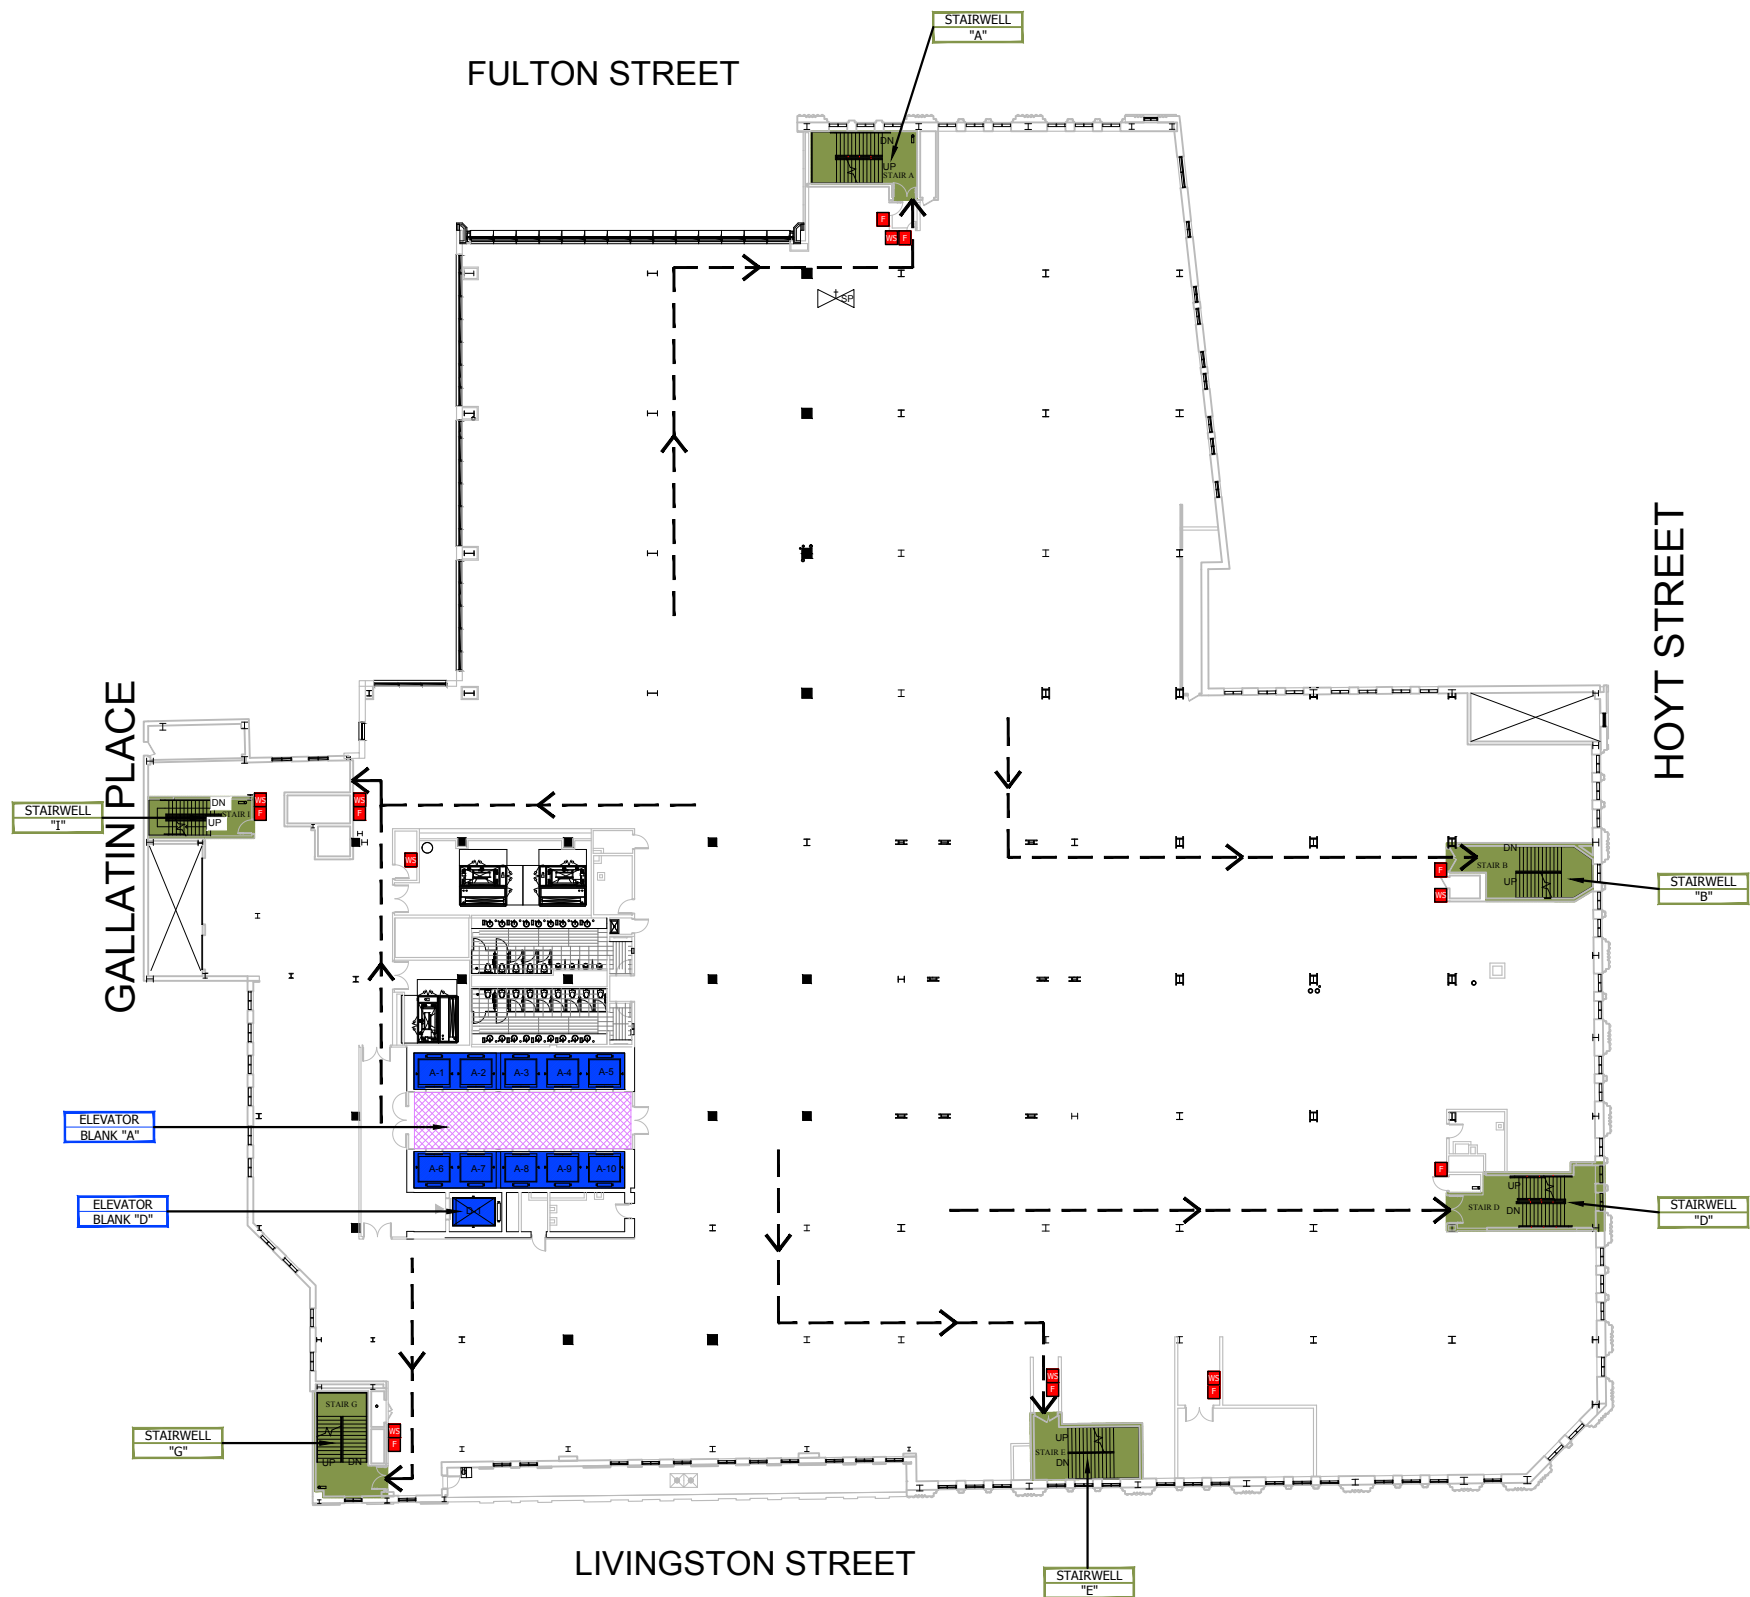

LEGEND:

 PULL STATION	 STANDPIPE/ SPRINKLER ISOLATION VALVE	 FDNY CONNECTION COMBINATION	 IN-BUILDING RELOCATION AREA  ELEVATOR CAR & NUMBER DESIGNATION  STAIRWELL  CONVENIENCE/ ACCESS STAIRS  MECHANICAL/ELECTRICAL SPACES (MER)  ELEVATOR BLIND SHAFT  NO ACCESS STAIRWELL	
 FIRE HOSE OUTLET	 SPRINKLER FLOOR CONTROL VALVE	 EVACUATION ROUTE		
 WARDEN STATION	 SPRINKLER OS&Y SECTION VALVE	 CONCRETE WALL		
 FIRE COMMAND STATION	 STANDPIPE ISOLATION VALVE			
 FIRE PUMP/ JOCKEY PUMP	 3 WAY MANIFOLD			



TOWER
CONSULTING ENGINEERS

120 West 31st Street - 7TH FLOOR
NEW YORK, N.Y. 10001
PHONE NO: (212) 444-8786
EMAIL: INFO@TOWERCE.COM
WWW.TOWERCE.COM

X	XX-XX-XXXX	XXXXXXXXXXXXX
NO.	DATE	DETAILS

THESE DRAWINGS ARE THE PROPERTY OF TOWER CONSULTING ENGINEERS (TCE). THEY MAY NOT BE COPIED, REPRODUCED, ALTERED OR DISTRIBUTED WITHOUT WRITTEN CONSENT FROM TCE. THESE PLANS SHALL BE USED FOR ONLY THE WORK TYPE INDICATED ON THE DRAWINGS. LICENSED CONTRACTOR(S)/VENDOR(S) SHALL CONFIRM ALL FIELD CONDITIONS INCLUDING BUT NOT LIMITED TO LOCATION, DIMENSIONS, APPLICABLE CODES FROM ALL AUTHORITIES HAVING JURISDICTION (AHJ) AND LAWS ENACTED PRIOR TO INITIATING ANY WORK AND NOTIFY TCE OF ANY CONFLICTS, DISCREPANCIES, ERRORS, AND OMISSIONS WITNESSED IN WRITING. INSTALLATION OF ANY SCOPE INDICATED ON THE DRAWINGS SHALL NOT COMMENCE UNTIL THE AHJ APPROVES ANY AND ALL SCOPES SHOWN. THIS APPROVAL SHALL BE INDICATED ON THE PLANS VIA AN APPROVAL STAMP. TCE SHALL BE DEEMED AS THE AUTHOR OF THESE DRAWINGS AND SHALL RETAIN ALL STATUTORY, COMMON LAWS, EDUCATION LAWS, AND ANY OTHER RESERVED RIGHTS INCLUDING COPYRIGHT. THE OWNER OF THE PREMISES SHALL BE ALLOWED TO RETAIN COPIES OF THE DRAWINGS, SPECIFICATIONS, AND OTHER DOCUMENTS FOR THIS PROJECT ONLY FOR THE WORK INDICATED ON THE DRAWINGS.

SEAL & SIGNATURE

AHJ STAMP

PROJECT NAME AND ADDRESS :

422 FULTON STREET
BROOKLYN, NY 11216

TITLE :


8TH FLOOR PLAN

FDNY RECORD ID #:

2022-EPPGFS-XXXXXX-PLAN


DATE: 07/13/2022
TCE JOB NUMBER: TISHAYK02
DRAWING BY: RAH
CHECK BY: MMZ
TCE TEAM LEAD: GIK
PROJECT MANAGER: ATY
DRAWING NUMBER:

NORTH ARROW

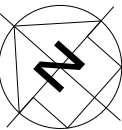

FL-9

SHEET:17 OF 27

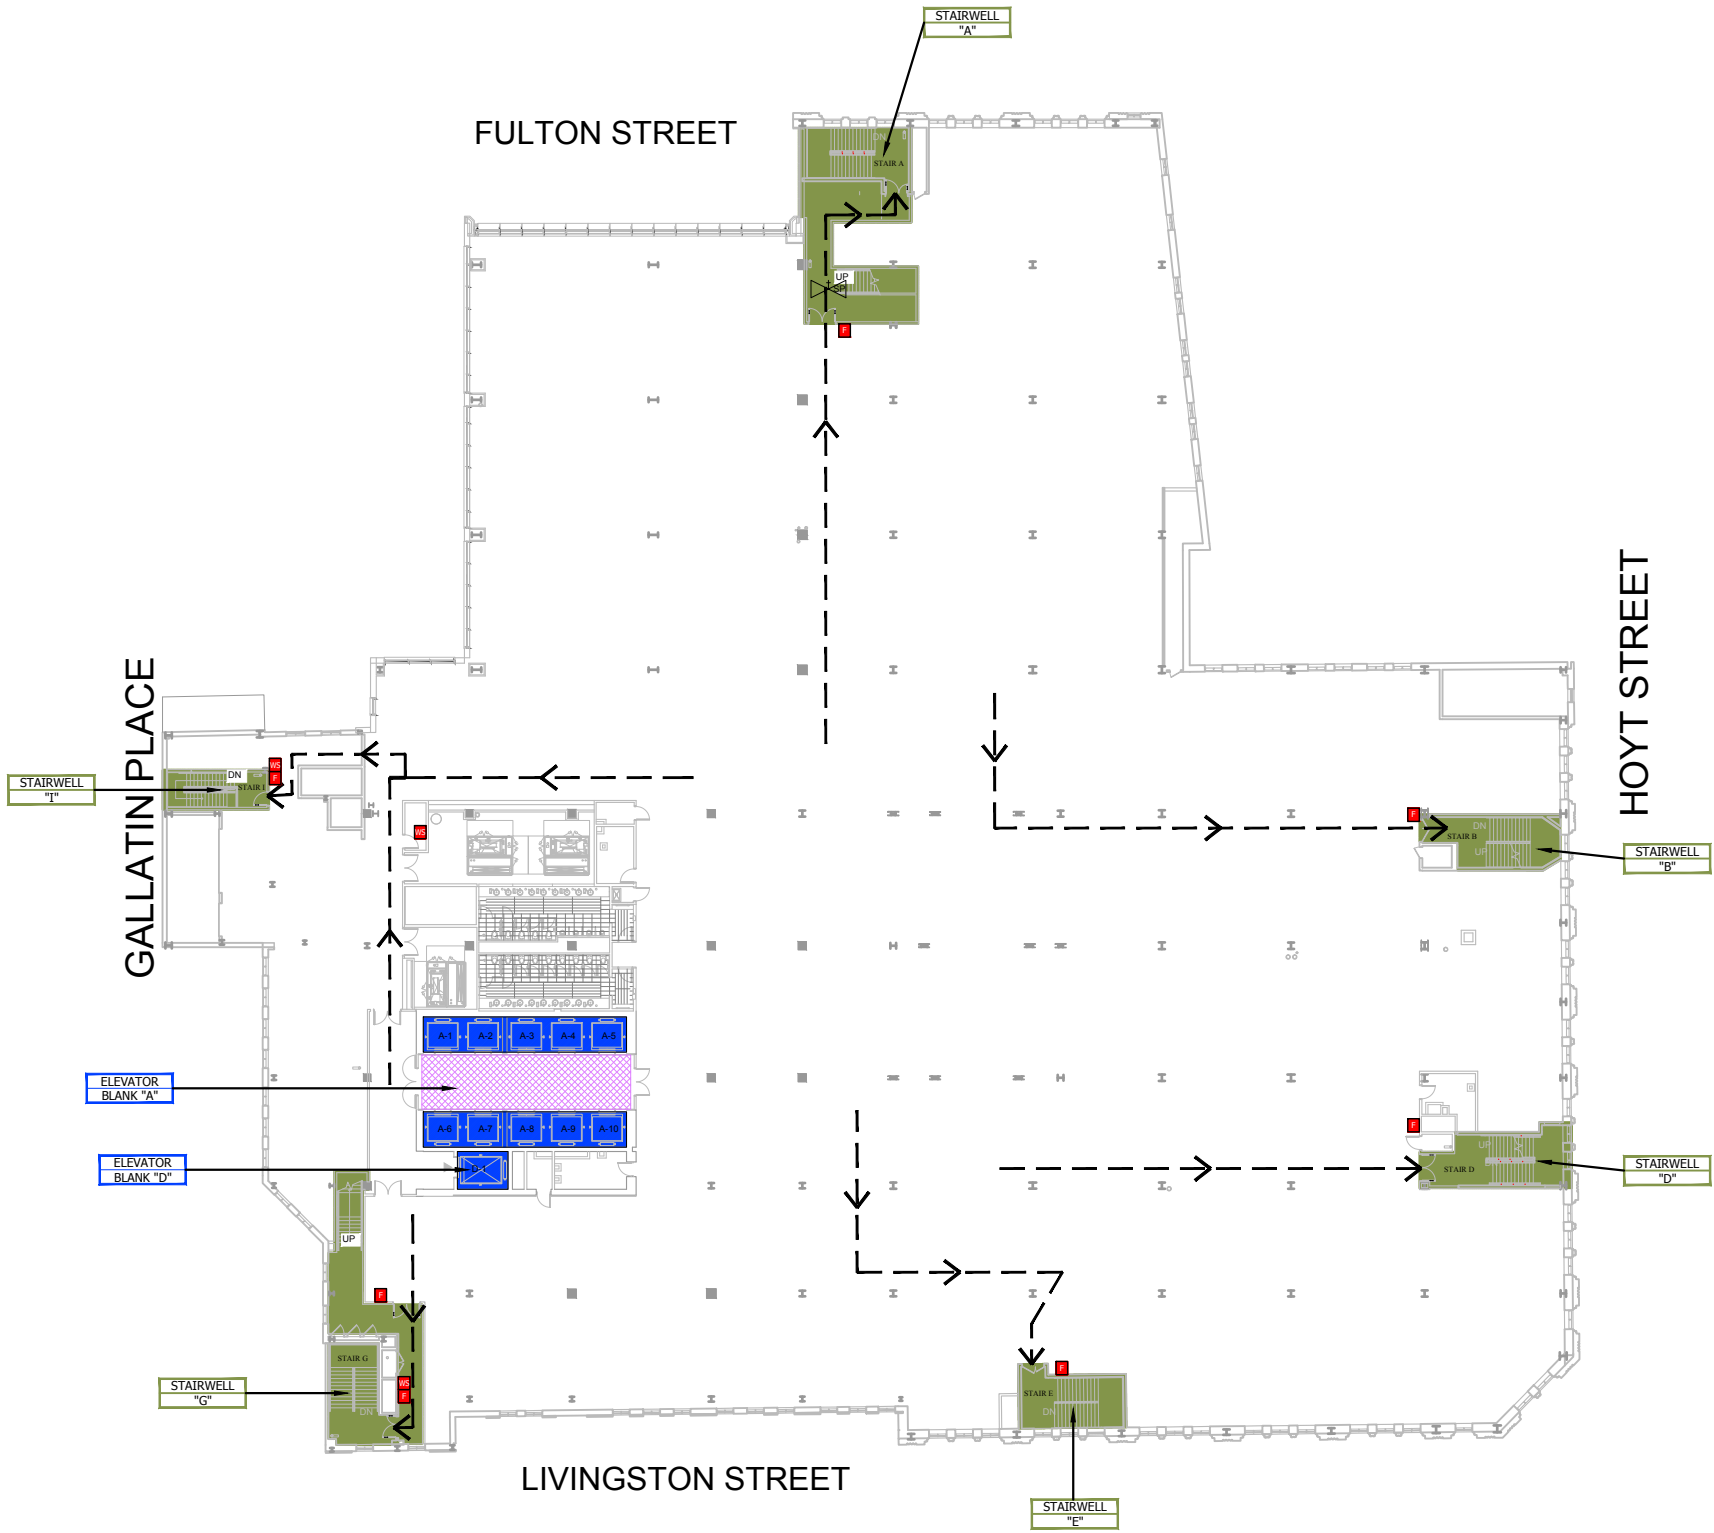

LEGEND:

F PULL STATION	STANDPIPE/ SPRINKLER ISOLATION VALVE	FDNY CONNECTION COMBINATION	IN-BUILDING RELOCATION AREA	MECHANICAL/ELECTRICAL SPACES (MER)	
FIRE HOSE OUTLET	SPRINKLER FLOOR CONTROL VALVE	EVACUATION ROUTE	ELEVATOR CAR & NUMBER DESIGNATION	ELEVATOR BLIND SHAFT	
WS WARDEN STATION	SPRINKLER OS&Y SECTION VALVE	CONCRETE WALL	STAIRWELL	NO ACCESS STAIRWELL	
FCC FIRE COMMAND STATION	STANDPIPE ISOLATION VALVE		CONVENIENCE/ ACCESS STAIRS		
FIRE PUMP/ JOCKEY PUMP	3 WAY MANIFOLD				



TOWER
CONSULTING ENGINEERS

120 West 31st Street - 7TH FLOOR
NEW YORK, N.Y. 10001
PHONE NO: (212) 444-8786
EMAIL: INFO@TOWERCE.COM
WWW.TOWERCE.COM

X	XX-XX-XXXX	XXXXXXXXXXXXX
NO.	DATE	DETAILS

THESE DRAWINGS ARE THE PROPERTY OF TOWER CONSULTING ENGINEERS (TCE). THEY MAY NOT BE COPIED, REPRODUCED, ALTERED OR DISTRIBUTED WITHOUT WRITTEN CONSENT FROM TCE. THESE PLANS SHALL BE USED FOR ONLY THE WORK TYPE INDICATED ON THE DRAWINGS. LICENSED CONTRACTOR(S)/VENDOR(S) SHALL CONFIRM ALL FIELD CONDITIONS INCLUDING BUT NOT LIMITED TO LOCATION, DIMENSIONS, APPLICABLE CODES FROM ALL AUTHORITIES HAVING JURISDICTION (AHJ) AND LAWS ENACTED PRIOR TO INITIATING ANY WORK AND NOTIFY TCE OF ANY CONFLICTS, DISCREPANCIES, ERRORS, AND OMISSIONS WITNESSED IN WRITING. INSTALLATION OF ANY SCOPE INDICATED ON THE DRAWINGS SHALL NOT COMMENCE UNTIL THE AHJ APPROVES ANY AND ALL SCOPES SHOWN. THIS APPROVAL SHALL BE INDICATED ON THE PLANS VIA AN APPROVAL STAMP. TCE SHALL BE DEEMED AS THE AUTHOR OF THESE DRAWINGS AND SHALL RETAIN ALL STATUTORY, COMMON LAWS, EDUCATION LAWS, AND ANY OTHER RESERVED RIGHTS INCLUDING COPYRIGHT. THE OWNER OF THE PREMISES SHALL BE ALLOWED TO RETAIN COPIES OF THE DRAWINGS, SPECIFICATIONS, AND OTHER DOCUMENTS FOR THIS PROJECT ONLY FOR THE WORK INDICATED ON THE DRAWINGS.

SEAL & SIGNATURE

AHJ STAMP

PROJECT NAME AND ADDRESS :

422 FULTON STREET
BROOKLYN, NY 11216

TITLE :


9TH FLOOR PLAN

FDNY RECORD ID #:

2022-EPPGFS-XXXXXX-PLAN

DATE:	07/13/2022
TCE JOB NUMBER:	TISHAYK02
DRAWING BY:	RAH
CHECK BY:	MMZ
TCE TEAM LEAD:	GIK
PROJECT MANAGER:	ATY
DRAWING NUMBER:	

NORTH ARROW

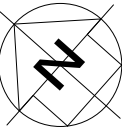

FL-10

SHEET:18OF 27



LEGEND:

PULL STATION	STANDPIPE/ SPRINKLER ISOLATION VALVE	FDNY CONNECTION COMBINATION	IN-BUILDING RELOCATION AREA	MECHANICAL/ELECTRICAL SPACES (MER)	
FIRE HOSE OUTLET	SPRINKLER FLOOR CONTROL VALVE	EVACUATION ROUTE	ELEVATOR CAR & NUMBER DESIGNATION	ELEVATOR BLIND SHAFT	
WARDEN STATION	SPRINKLER OS&Y SECTION VALVE	CONCRETE WALL	STAIRWELL	NO ACCESS STAIRWELL	
FIRE COMMAND STATION	STANDPIPE ISOLATION VALVE		CONVENIENCE/ ACCESS STAIRS		
FIRE PUMP/ JOCKEY PUMP	3 WAY MANIFOLD				



TOWER
CONSULTING ENGINEERS

120 West 31st Street - 7TH FLOOR
NEW YORK, N.Y. 10001
PHONE NO: (212) 444-8786
EMAIL: INFO@TOWERCE.COM
WWW.TOWERCE.COM

X	XX-XX-XXXX	XXXXXXXXXXXXX
NO.	DATE	DETAILS

THESE DRAWINGS ARE THE PROPERTY OF TOWER CONSULTING ENGINEERS (TCE). THEY MAY NOT BE COPIED, REPRODUCED, ALTERED OR DISTRIBUTED WITHOUT WRITTEN CONSENT FROM TCE. THESE PLANS SHALL BE USED FOR ONLY THE WORK TYPE INDICATED ON THE DRAWINGS. LICENSED CONTRACTOR(S)/VENDOR(S) SHALL CONFIRM ALL FIELD CONDITIONS INCLUDING BUT NOT LIMITED TO LOCATION, DIMENSIONS, APPLICABLE CODES FROM ALL AUTHORITIES HAVING JURISDICTION (AHJ) AND LAWS ENACTED PRIOR TO INITIATING ANY WORK AND NOTIFY TCE OF ANY CONFLICTS, DISCREPANCIES, ERRORS, AND OMISSIONS WITNESSED IN WRITING. INSTALLATION OF ANY SCOPE INDICATED ON THE DRAWINGS SHALL NOT COMMENCE UNTIL THE AHJ APPROVES ANY AND ALL SCOPES SHOWN. THIS APPROVAL SHALL BE INDICATED ON THE PLANS VIA AN APPROVAL STAMP. TCE SHALL BE DEEMED AS THE AUTHOR OF THESE DRAWINGS AND SHALL RETAIN ALL STATUTORY, COMMON LAWS, EDUCATION LAWS, AND ANY OTHER RESERVED RIGHTS INCLUDING COPYRIGHT. THE OWNER OF THE PREMISES SHALL BE ALLOWED TO RETAIN COPIES OF THE DRAWINGS, SPECIFICATIONS, AND OTHER DOCUMENTS FOR THIS PROJECT ONLY FOR THE WORK INDICATED ON THE DRAWINGS.

SEAL & SIGNATURE

AHJ STAMP

PROJECT NAME AND ADDRESS :

422 FULTON STREET
BROOKLYN, NY 11216

TITLE :


10TH FLOOR PLAN

FDNY RECORD ID #:

2022-EPPGFS-XXXXXX-PLAN

DATE: 07/13/2022
TCE JOB NUMBER: TISHAYK02
DRAWING BY: RAH
CHECK BY: MMZ
TCE TEAM LEAD: GIK
PROJECT MANAGER: ATY
DRAWING NUMBER:

NORTH ARROW

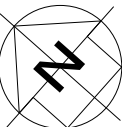

FL-11

SHEET:19OF 27

FULTON STREET


GALLATIN PLACE

HOYT STREET

LIVINGSTON STREET

LEGEND:

PULL STATION	STANDPIPE/ SPRINKLER ISOLATION VALVE	FDNY CONNECTION COMBINATION	IN-BUILDING RELOCATION AREA	MECHANICAL/ELECTRICAL SPACES (MER)	
FIRE HOSE OUTLET	SPRINKLER FLOOR CONTROL VALVE	EVACUATION ROUTE	ELEVATOR CAR & NUMBER DESIGNATION	ELEVATOR BLIND SHAFT	
WARDEN STATION	SPRINKLER OS&Y SECTION VALVE	CONCRETE WALL	STAIRWELL	NO ACCESS STAIRWELL	
FIRE COMMAND STATION	STANDPIPE ISOLATION VALVE		CONVENIENCE/ ACCESS STAIRS		
FIRE PUMP/ JOCKEY PUMP	3 WAY MANIFOLD				

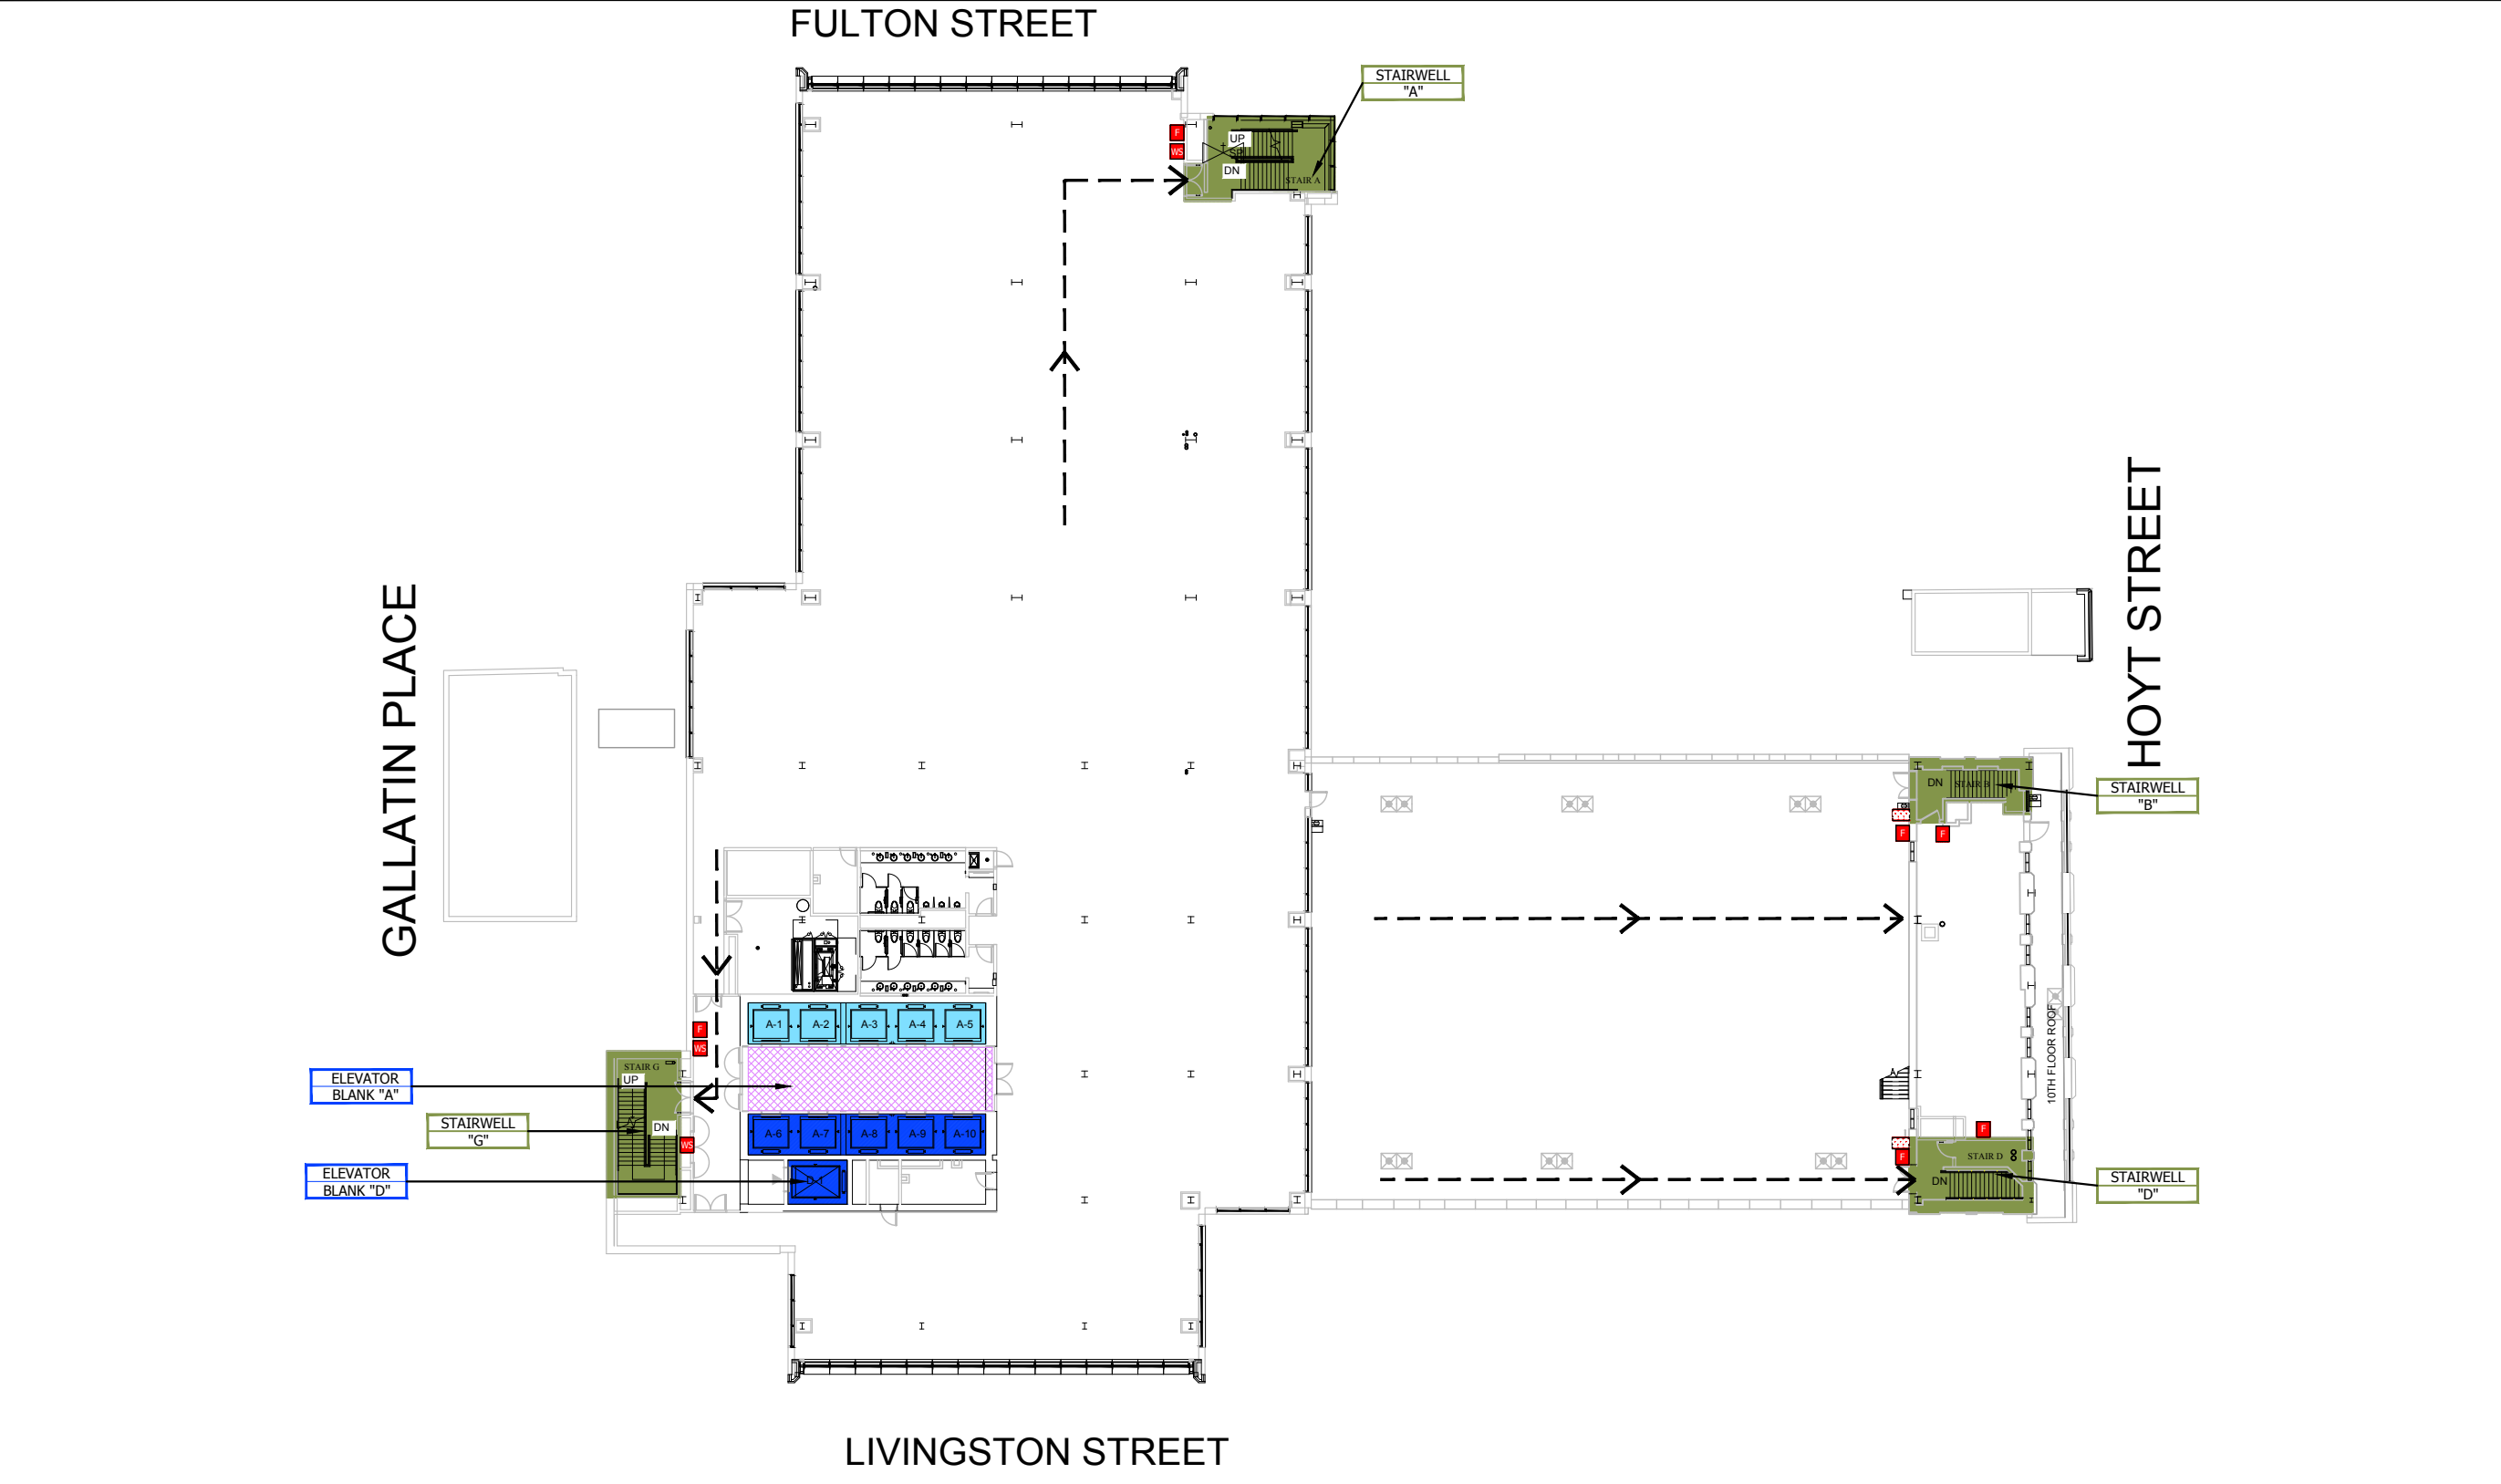



TOWER
CONSULTING ENGINEERS

120 West 31st Street - 7TH FLOOR
NEW YORK, N.Y. 10001
PHONE NO: (212) 444-8786
EMAIL: INFO@TOWERCE.COM
WWW.TOWERCE.COM

X	XX-XX-XXXX	XXXXXXXXXXXXX
NO.	DATE	DETAILS

THESE DRAWINGS ARE THE PROPERTY OF TOWER CONSULTING ENGINEERS (TCE). THEY MAY NOT BE COPIED, REPRODUCED, ALTERED OR DISTRIBUTED WITHOUT WRITTEN CONSENT FROM TCE. THESE PLANS SHALL BE USED FOR ONLY THE WORK TYPE INDICATED ON THE DRAWINGS. LICENSED CONTRACTOR(S)/VENDOR(S) SHALL CONFIRM ALL FIELD CONDITIONS INCLUDING BUT NOT LIMITED TO LOCATION, DIMENSIONS, APPLICABLE CODES FROM ALL AUTHORITIES HAVING JURISDICTION (AHJ) AND LAWS ENACTED PRIOR TO INITIATING ANY WORK AND NOTIFY TCE OF ANY CONFLICTS, DISCREPANCIES, ERRORS, AND OMISSIONS WITNESSED IN WRITING. INSTALLATION OF ANY SCOPE INDICATED ON THE DRAWINGS SHALL NOT COMMENCE UNTIL THE AHJ APPROVES ANY AND ALL SCOPES SHOWN. THIS APPROVAL SHALL BE INDICATED ON THE PLANS VIA AN APPROVAL STAMP. TCE SHALL BE DEEMED AS THE AUTHOR OF THESE DRAWINGS AND SHALL RETAIN ALL STATUTORY, COMMON LAWS, EDUCATION LAWS, AND ANY OTHER RESERVED RIGHTS INCLUDING COPYRIGHT. THE OWNER OF THE PREMISES SHALL BE ALLOWED TO RETAIN COPIES OF THE DRAWINGS, SPECIFICATIONS, AND OTHER DOCUMENTS FOR THIS PROJECT ONLY FOR THE WORK INDICATED ON THE DRAWINGS.

SEAL & SIGNATURE

AHJ STAMP

PROJECT NAME AND ADDRESS :

422 FULTON STREET
BROOKLYN, NY 11216

TITLE :

11TH FLOOR PLAN

FDNY RECORD ID #:

2022-EPPGFS-XXXXXX-PLAN

DATE: 07/13/2022

TCE JOB NUMBER: TISHAYK02

DRAWING BY: RAH


CHECK BY: MMZ

TCE TEAM LEAD: GIK

PROJECT MANAGER: ATY

DRAWING NUMBER:


NORTH ARROW

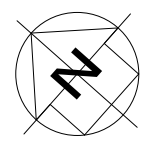

FL-12

SHEET:20OF 27

LEGEND:

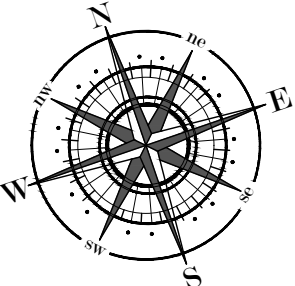 PULL STATION	 STANDPIPE/ SPRINKLER ISOLATION VALVE	 FDNY CONNECTION COMBINATION	 IN-BUILDING RELOCATION AREA	 MECHANICAL/ELECTRICAL SPACES (MER)	
 FIRE HOSE OUTLET	 SPRINKLER FLOOR CONTROL VALVE	 EVACUATION ROUTE	 ELEVATOR CAR & NUMBER DESIGNATION	 ELEVATOR BLIND SHAFT	
 WARDEN STATION	 SPRINKLER OS&Y SECTION VALVE	 CONCRETE WALL	 STAIRWELL	 NO ACCESS STAIRWELL	
 FIRE COMMAND STATION	 STANDPIPE ISOLATION VALVE		 CONVENIENCE/ ACCESS STAIRS		
 FIRE PUMP/ JOCKEY PUMP	 3 WAY MANIFOLD				



TOWER
CONSULTING ENGINEERS

120 West 31st Street - 7TH FLOOR
NEW YORK, N.Y. 10001
PHONE NO: (212) 444-8786
EMAIL: INFO@TOWERCE.COM
WWW.TOWERCE.COM

X	XX-XX-XXXX	XXXXXXXXXXXXX
NO.	DATE	DETAILS

THESE DRAWINGS ARE THE PROPERTY OF TOWER CONSULTING ENGINEERS (TCE). THEY MAY NOT BE COPIED, REPRODUCED, ALTERED OR DISTRIBUTED WITHOUT WRITTEN CONSENT FROM TCE. THESE PLANS SHALL BE USED FOR ONLY THE WORK TYPE INDICATED ON THE DRAWINGS. LICENSED CONTRACTOR(S)/VENDOR(S) SHALL CONFIRM ALL FIELD CONDITIONS INCLUDING BUT NOT LIMITED TO LOCATION, DIMENSIONS, APPLICABLE CODES FROM ALL AUTHORITIES HAVING JURISDICTION (AHJ) AND LAWS ENACTED PRIOR TO INITIATING ANY WORK AND NOTIFY TCE OF ANY CONFLICTS, DISCREPANCIES, ERRORS, AND OMISSIONS WITNESSED IN WRITING. INSTALLATION OF ANY SCOPE INDICATED ON THE DRAWINGS SHALL NOT COMMENCE UNTIL THE AHJ APPROVES ANY AND ALL SCOPES SHOWN. THIS APPROVAL SHALL BE INDICATED ON THE PLANS VIA AN APPROVAL STAMP. TCE SHALL BE DEEMED AS THE AUTHOR OF THESE DRAWINGS AND SHALL RETAIN ALL STATUTORY, COMMON LAWS, EDUCATION LAWS, AND ANY OTHER RESERVED RIGHTS INCLUDING COPYRIGHT. THE OWNER OF THE PREMISES SHALL BE ALLOWED TO RETAIN COPIES OF THE DRAWINGS, SPECIFICATIONS, AND OTHER DOCUMENTS FOR THIS PROJECT ONLY FOR THE WORK INDICATED ON THE DRAWINGS.

SEAL & SIGNATURE

AHJ STAMP

PROJECT NAME AND ADDRESS :

422 FULTON STREET
BROOKLYN, NY 11216

TITLE :

12TH FLOOR PLAN

FDNY RECORD ID #:

2022-EPPGFS-XXXXXX-PLAN

DATE:	07/13/2022
TCE JOB NUMBER:	TISHAYK02
DRAWING BY:	RAH
CHECK BY:	MMZ
TCE TEAM LEAD:	GIK
PROJECT MANAGER:	ATY
DRAWING NUMBER:	

NORTH ARROW



FL-13



SHEET:21OF 27

FULTON STREET

HOYT STREET

GALLATIN PLACE

LIVINGSTON STREET

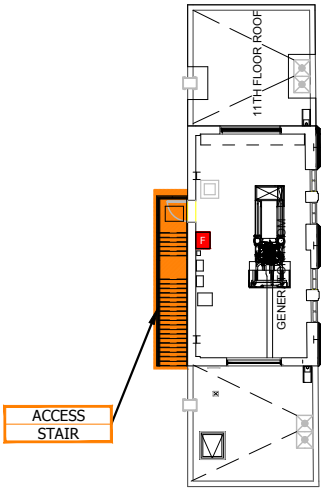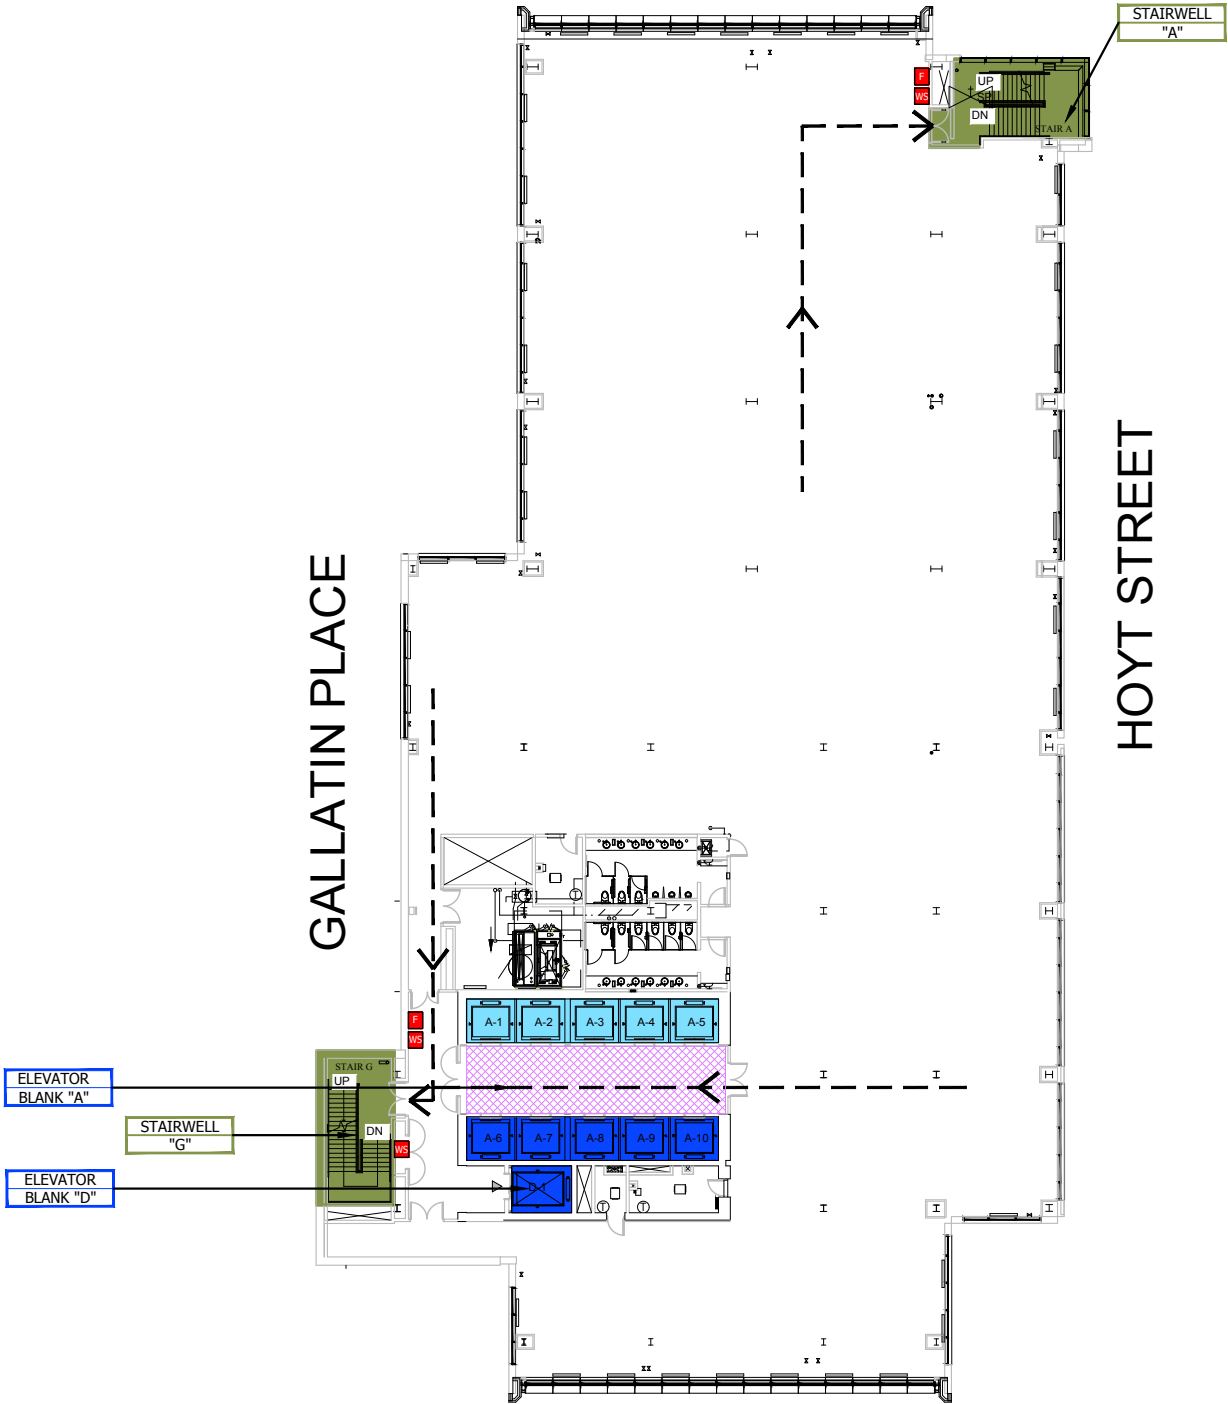

LEGEND:

PULL STATION	STANDPIPE/ SPRINKLER ISOLATION VALVE	FDNY CONNECTION COMBINATION	IN-BUILDING RELOCATION AREA	MECHANICAL/ELECTRICAL SPACES (MER)	
FIRE HOSE OUTLET	SPRINKLER FLOOR CONTROL VALVE	EVACUATION ROUTE	ELEVATOR CAR & NUMBER DESIGNATION	ELEVATOR BLIND SHAFT	
WARDEN STATION	SPRINKLER OS&Y SECTION VALVE	CONCRETE WALL	STAIRWELL	NO ACCESS STAIRWELL	
FIRE COMMAND STATION	STANDPIPE ISOLATION VALVE		CONVENIENCE/ ACCESS STAIRS		
FIRE PUMP/ JOCKEY PUMP	3 WAY MANIFOLD				



TOWER
CONSULTING ENGINEERS

120 West 31st Street - 7TH FLOOR
NEW YORK, N.Y. 10001
PHONE NO: (212) 444-8786
EMAIL: INFO@TOWERCE.COM
WWW.TOWERCE.COM

X	XX-XX-XXXX	XXXXXXXXXXXXX
NO.	DATE	DETAILS

THESE DRAWINGS ARE THE PROPERTY OF TOWER CONSULTING ENGINEERS (TCE). THEY MAY NOT BE COPIED, REPRODUCED, ALTERED OR DISTRIBUTED WITHOUT WRITTEN CONSENT FROM TCE. THESE PLANS SHALL BE USED FOR ONLY THE WORK TYPE INDICATED ON THE DRAWINGS. LICENSED CONTRACTOR(S)/VENDOR(S) SHALL CONFIRM ALL FIELD CONDITIONS INCLUDING BUT NOT LIMITED TO LOCATION, DIMENSIONS, APPLICABLE CODES FROM ALL AUTHORITIES HAVING JURISDICTION (AHJ) AND LAWS ENACTED PRIOR TO INITIATING ANY WORK AND NOTIFY TCE OF ANY CONFLICTS, DISCREPANCIES, ERRORS, AND OMISSIONS WITNESSED IN WRITING. INSTALLATION OF ANY SCOPE INDICATED ON THE DRAWINGS SHALL NOT COMMENCE UNTIL THE AHJ APPROVES ANY AND ALL SCOPES SHOWN. THIS APPROVAL SHALL BE INDICATED ON THE PLANS VIA AN APPROVAL STAMP. TCE SHALL BE DEEMED AS THE AUTHOR OF THESE DRAWINGS AND SHALL RETAIN ALL STATUTORY, COMMON LAWS, EDUCATION LAWS, AND ANY OTHER RESERVED RIGHTS INCLUDING COPYRIGHT. THE OWNER OF THE PREMISES SHALL BE ALLOWED TO RETAIN COPIES OF THE DRAWINGS, SPECIFICATIONS, AND OTHER DOCUMENTS FOR THIS PROJECT ONLY FOR THE WORK INDICATED ON THE DRAWINGS.

SEAL & SIGNATURE

AHJ STAMP

PROJECT NAME AND ADDRESS :

422 FULTON STREET
BROOKLYN, NY 11216

TITLE :


13TH FLOOR PLAN

FDNY RECORD ID #:

2022-EPPGFS-XXXXXX-PLAN

DATE: 07/13/2022
TCE JOB NUMBER: TISHAYK02
DRAWING BY: RAH
CHECK BY: MMZ
TCE TEAM LEAD: GIK
PROJECT MANAGER: ATY
DRAWING NUMBER:

NORTH ARROW

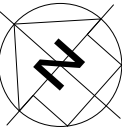

FL-14



SHEET:22OF 27

FULTON STREET

HOYT STREET

GALLATIN PLACE

LIVINGSTON STREET

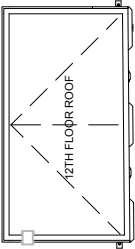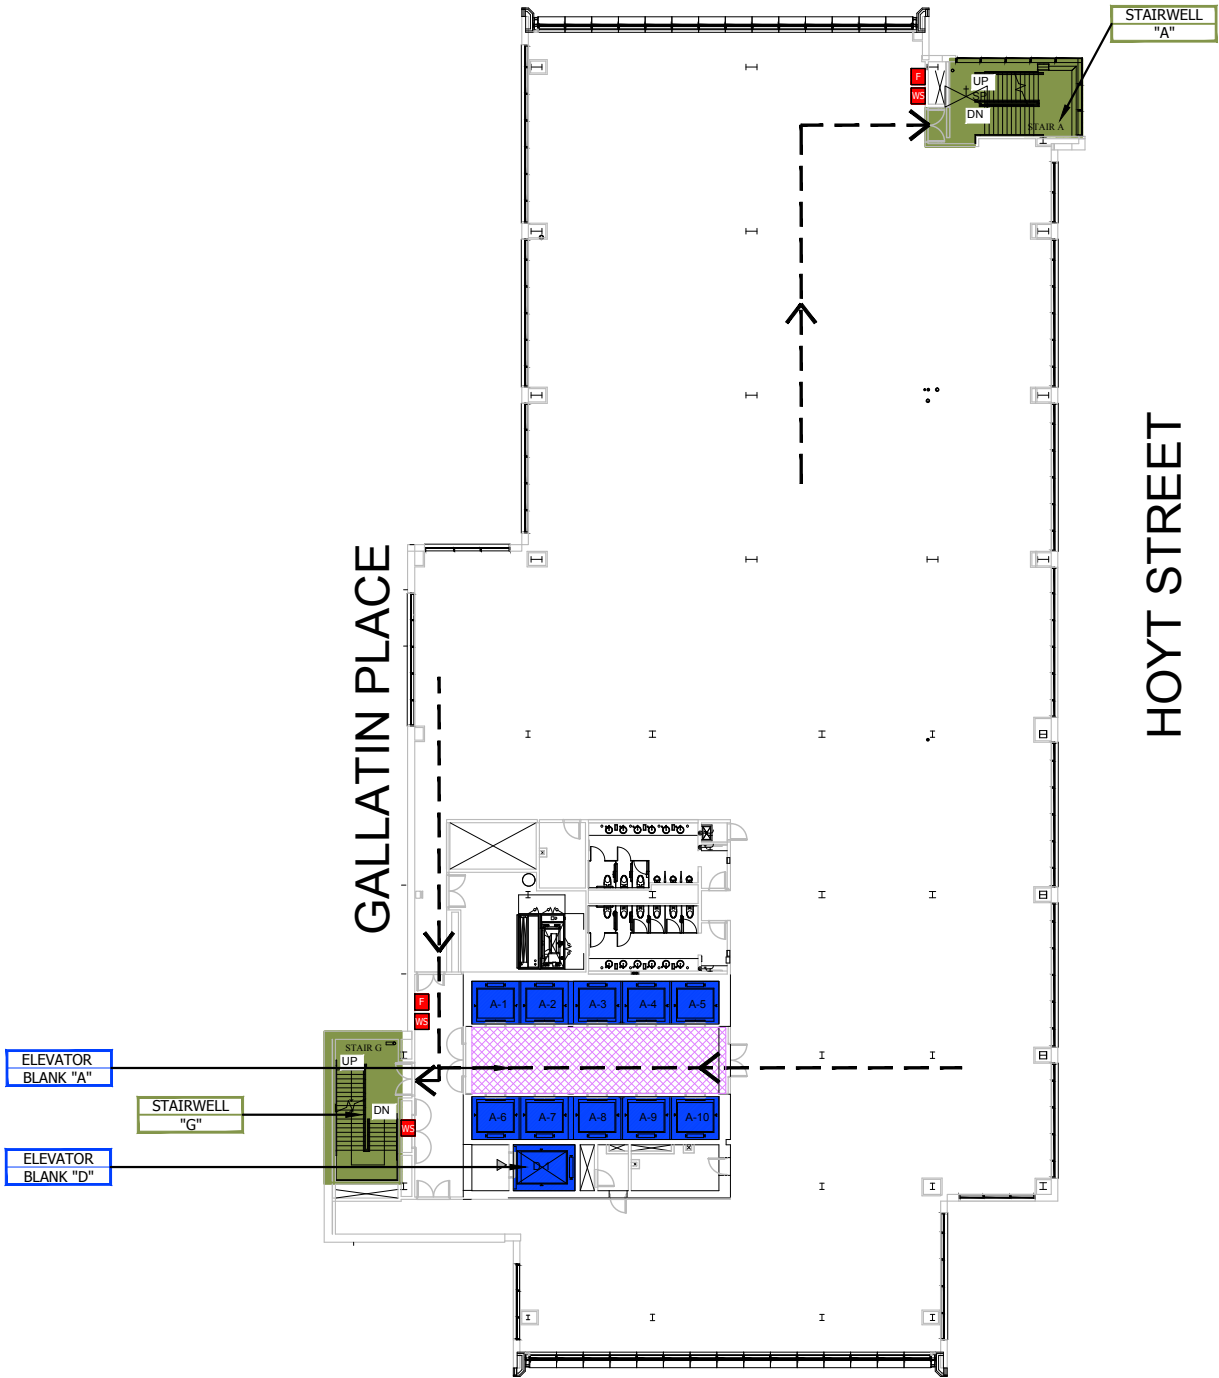

LEGEND:

PULL STATION	STANDPIPE/ SPRINKLER ISOLATION VALVE	FDNY CONNECTION COMBINATION	IN-BUILDING RELOCATION AREA	MECHANICAL/ELECTRICAL SPACES (MER)	
FIRE HOSE OUTLET	SPRINKLER FLOOR CONTROL VALVE	EVACUATION ROUTE	ELEVATOR CAR & NUMBER DESIGNATION	ELEVATOR BLIND SHAFT	
WARDEN STATION	SPRINKLER OS&Y SECTION VALVE	CONCRETE WALL	STAIRWELL	NO ACCESS STAIRWELL	
FIRE COMMAND STATION	STANDPIPE ISOLATION VALVE		CONVENIENCE/ ACCESS STAIRS		
FIRE PUMP/ JOCKEY PUMP	3 WAY MANIFOLD				



120 West 31st Street - 7TH FLOOR
NEW YORK, N.Y. 10001
PHONE NO: (212) 444-8786
EMAIL: INFO@TOWERCE.COM
WWW.TOWERCE.COM

X	XX-XX-XXXX	XXXXXXXXXXXXX
NO.	DATE	DETAILS

THESE DRAWINGS ARE THE PROPERTY OF TOWER CONSULTING ENGINEERS (TCE). THEY MAY NOT BE COPIED, REPRODUCED, ALTERED OR DISTRIBUTED WITHOUT WRITTEN CONSENT FROM TCE. THESE PLANS SHALL BE USED FOR ONLY THE WORK TYPE INDICATED ON THE DRAWINGS. LICENSED CONTRACTOR(S)/VENDOR(S) SHALL CONFIRM ALL FIELD CONDITIONS INCLUDING BUT NOT LIMITED TO LOCATION, DIMENSIONS, APPLICABLE CODES FROM ALL AUTHORITIES HAVING JURISDICTION (AHJ) AND LAWS ENACTED PRIOR TO INITIATING ANY WORK AND NOTIFY TCE OF ANY CONFLICTS, DISCREPANCIES, ERRORS, AND OMISSIONS WITNESSED IN WRITING. INSTALLATION OF ANY SCOPE INDICATED ON THE DRAWINGS SHALL NOT COMMENCE UNTIL THE AHJ APPROVES ANY AND ALL SCOPES SHOWN. THIS APPROVAL SHALL BE INDICATED ON THE PLANS VIA AN APPROVAL STAMP. TCE SHALL BE DEEMED AS THE AUTHOR OF THESE DRAWINGS AND SHALL RETAIN ALL STATUTORY, COMMON LAWS, EDUCATION LAWS, AND ANY OTHER RESERVED RIGHTS INCLUDING COPYRIGHT. THE OWNER OF THE PREMISES SHALL BE ALLOWED TO RETAIN COPIES OF THE DRAWINGS, SPECIFICATIONS, AND OTHER DOCUMENTS FOR THIS PROJECT ONLY FOR THE WORK INDICATED ON THE DRAWINGS.

SEAL & SIGNATURE

AHJ STAMP

PROJECT NAME AND ADDRESS :

422 FULTON STREET
BROOKLYN, NY 11216

TITLE :


14TH FLOOR PLAN

FDNY RECORD ID #:

2022-EPPGFS-XXXXXX-PLAN

DATE:	07/13/2022
TCE JOB NUMBER:	TISHAYK02
DRAWING BY:	RAH
CHECK BY:	MMZ
TCE TEAM LEAD:	GJK
PROJECT MANAGER:	ATY
DRAWING NUMBER:	

NORTH ARROW

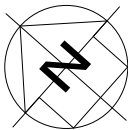

FL-15


SHEET:23OF 27

FULTON STREET

HOYT STREET

GALLATIN PLACE

LIVINGSTON STREET

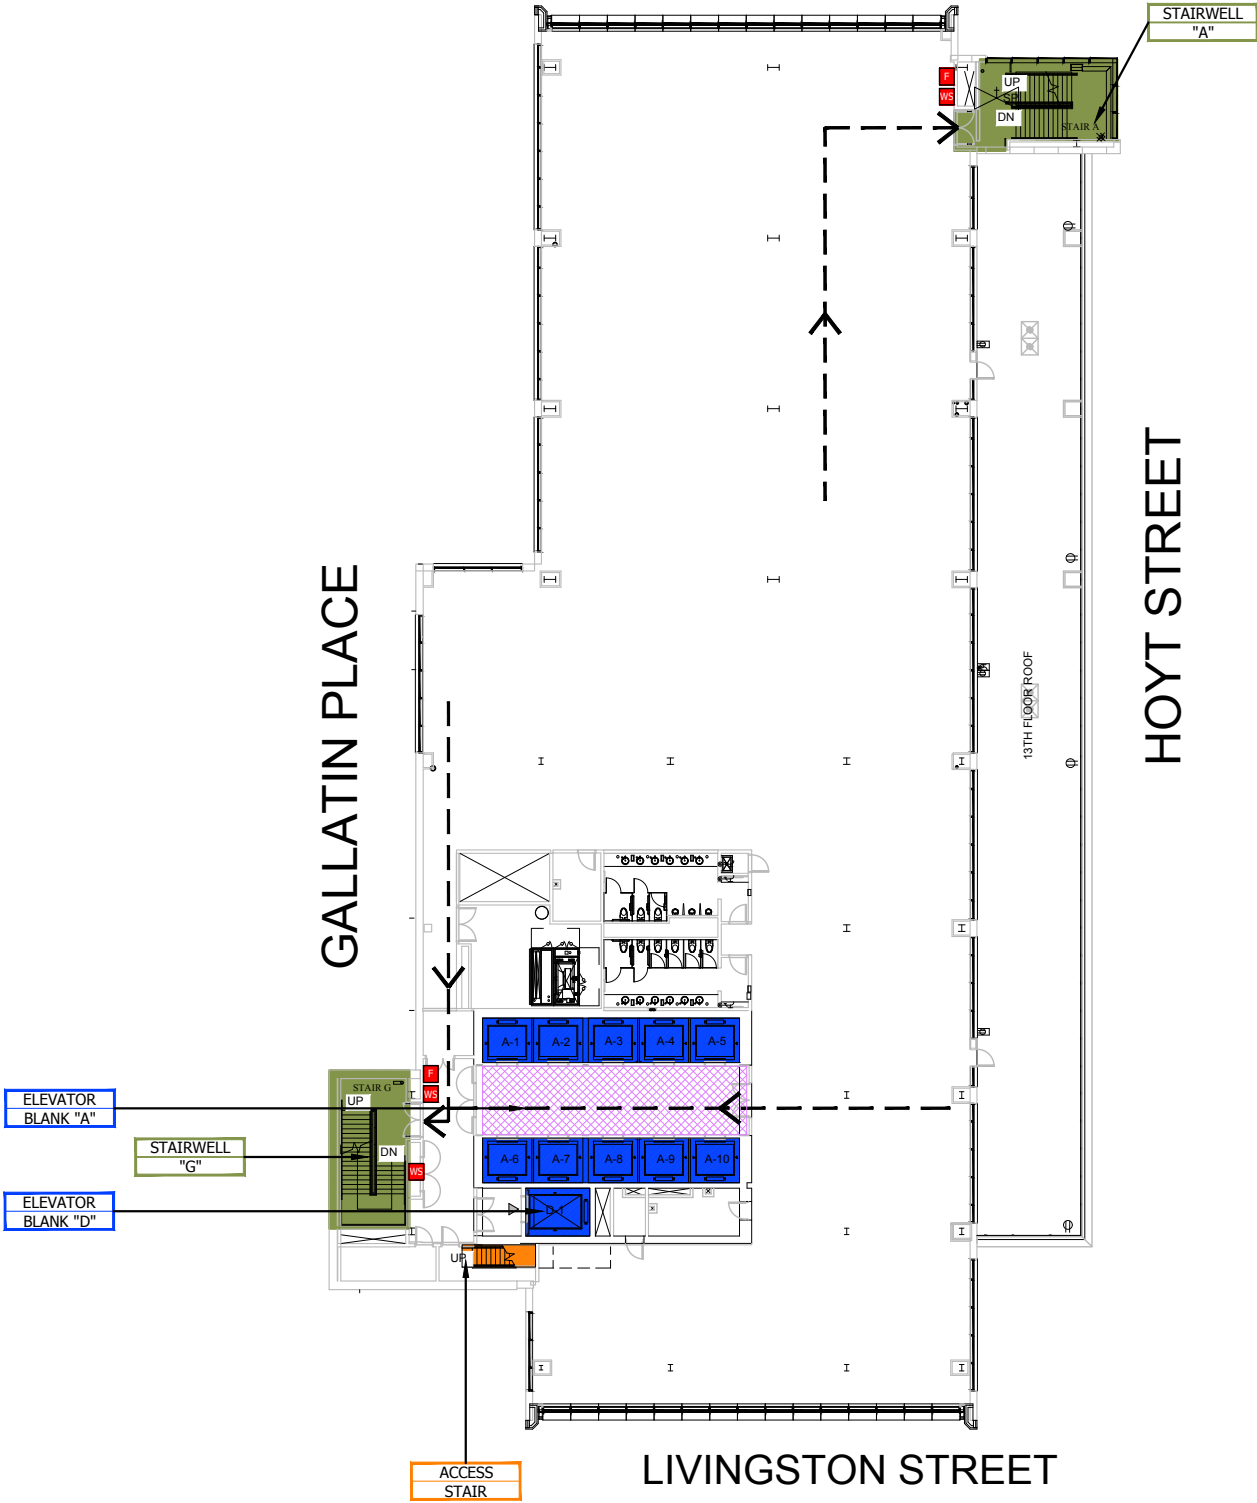

LEGEND:

PULL STATION	STANDPIPE/ SPRINKLER ISOLATION VALVE	FDNY CONNECTION COMBINATION	IN-BUILDING RELOCATION AREA	MECHANICAL/ELECTRICAL SPACES (MER)	
FIRE HOSE OUTLET	SPRINKLER FLOOR CONTROL VALVE	EVACUATION ROUTE	ELEVATOR CAR & NUMBER DESIGNATION	ELEVATOR BLIND SHAFT	
WARDEN STATION	SPRINKLER OS&Y SECTION VALVE	CONCRETE WALL	STAIRWELL	NO ACCESS STAIRWELL	
FIRE COMMAND STATION	STANDPIPE ISOLATION VALVE		CONVENIENCE/ ACCESS STAIRS		
FIRE PUMP/ JOCKEY PUMP	3 WAY MANIFOLD				



TOWER
CONSULTING ENGINEERS

120 West 31st Street - 7TH FLOOR
NEW YORK, N.Y. 10001
PHONE NO: (212) 444-8786
EMAIL: INFO@TOWERCE.COM
WWW.TOWERCE.COM

X	XX-XX-XXXX	XXXXXXXXXXXXX
NO.	DATE	DETAILS

THESE DRAWINGS ARE THE PROPERTY OF TOWER CONSULTING ENGINEERS (TCE). THEY MAY NOT BE COPIED, REPRODUCED, ALTERED OR DISTRIBUTED WITHOUT WRITTEN CONSENT FROM TCE. THESE PLANS SHALL BE USED FOR ONLY THE WORK TYPE INDICATED ON THE DRAWINGS. LICENSED CONTRACTOR(S)/VENDOR(S) SHALL CONFIRM ALL FIELD CONDITIONS INCLUDING BUT NOT LIMITED TO LOCATION, DIMENSIONS, APPLICABLE CODES FROM ALL AUTHORITIES HAVING JURISDICTION (AHJ) AND LAWS ENACTED PRIOR TO INITIATING ANY WORK AND NOTIFY TCE OF ANY CONFLICTS, DISCREPANCIES, ERRORS, AND OMISSIONS WITNESSED IN WRITING. INSTALLATION OF ANY SCOPE INDICATED ON THE DRAWINGS SHALL NOT COMMENCE UNTIL THE AHJ APPROVES ANY AND ALL SCOPES SHOWN. THIS APPROVAL SHALL BE INDICATED ON THE PLANS VIA AN APPROVAL STAMP. TCE SHALL BE DEEMED AS THE AUTHOR OF THESE DRAWINGS AND SHALL RETAIN ALL STATUTORY, COMMON LAWS, EDUCATION LAWS, AND ANY OTHER RESERVED RIGHTS INCLUDING COPYRIGHT. THE OWNER OF THE PREMISES SHALL BE ALLOWED TO RETAIN COPIES OF THE DRAWINGS, SPECIFICATIONS, AND OTHER DOCUMENTS FOR THIS PROJECT ONLY FOR THE WORK INDICATED ON THE DRAWINGS.

SEAL & SIGNATURE

AHJ STAMP

PROJECT NAME AND ADDRESS :

422 FULTON STREET
BROOKLYN, NY 11216

TITLE :


PENTHOUSE 1/MAIN ROOF

FDNY RECORD ID #:

2022-EPPGFS-XXXXXX-PLAN

DATE:	07/13/2022
TCE JOB NUMBER:	TISHAYK02
DRAWING BY:	RAH
CHECK BY:	MMZ
TCE TEAM LEAD:	GIK
PROJECT MANAGER:	ATY
DRAWING NUMBER:	

NORTH ARROW

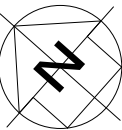

FL-16


SHEET:24OF 27

FULTON STREET

HOYT STREET


GALLATIN PLACE

LIVINGSTON STREET

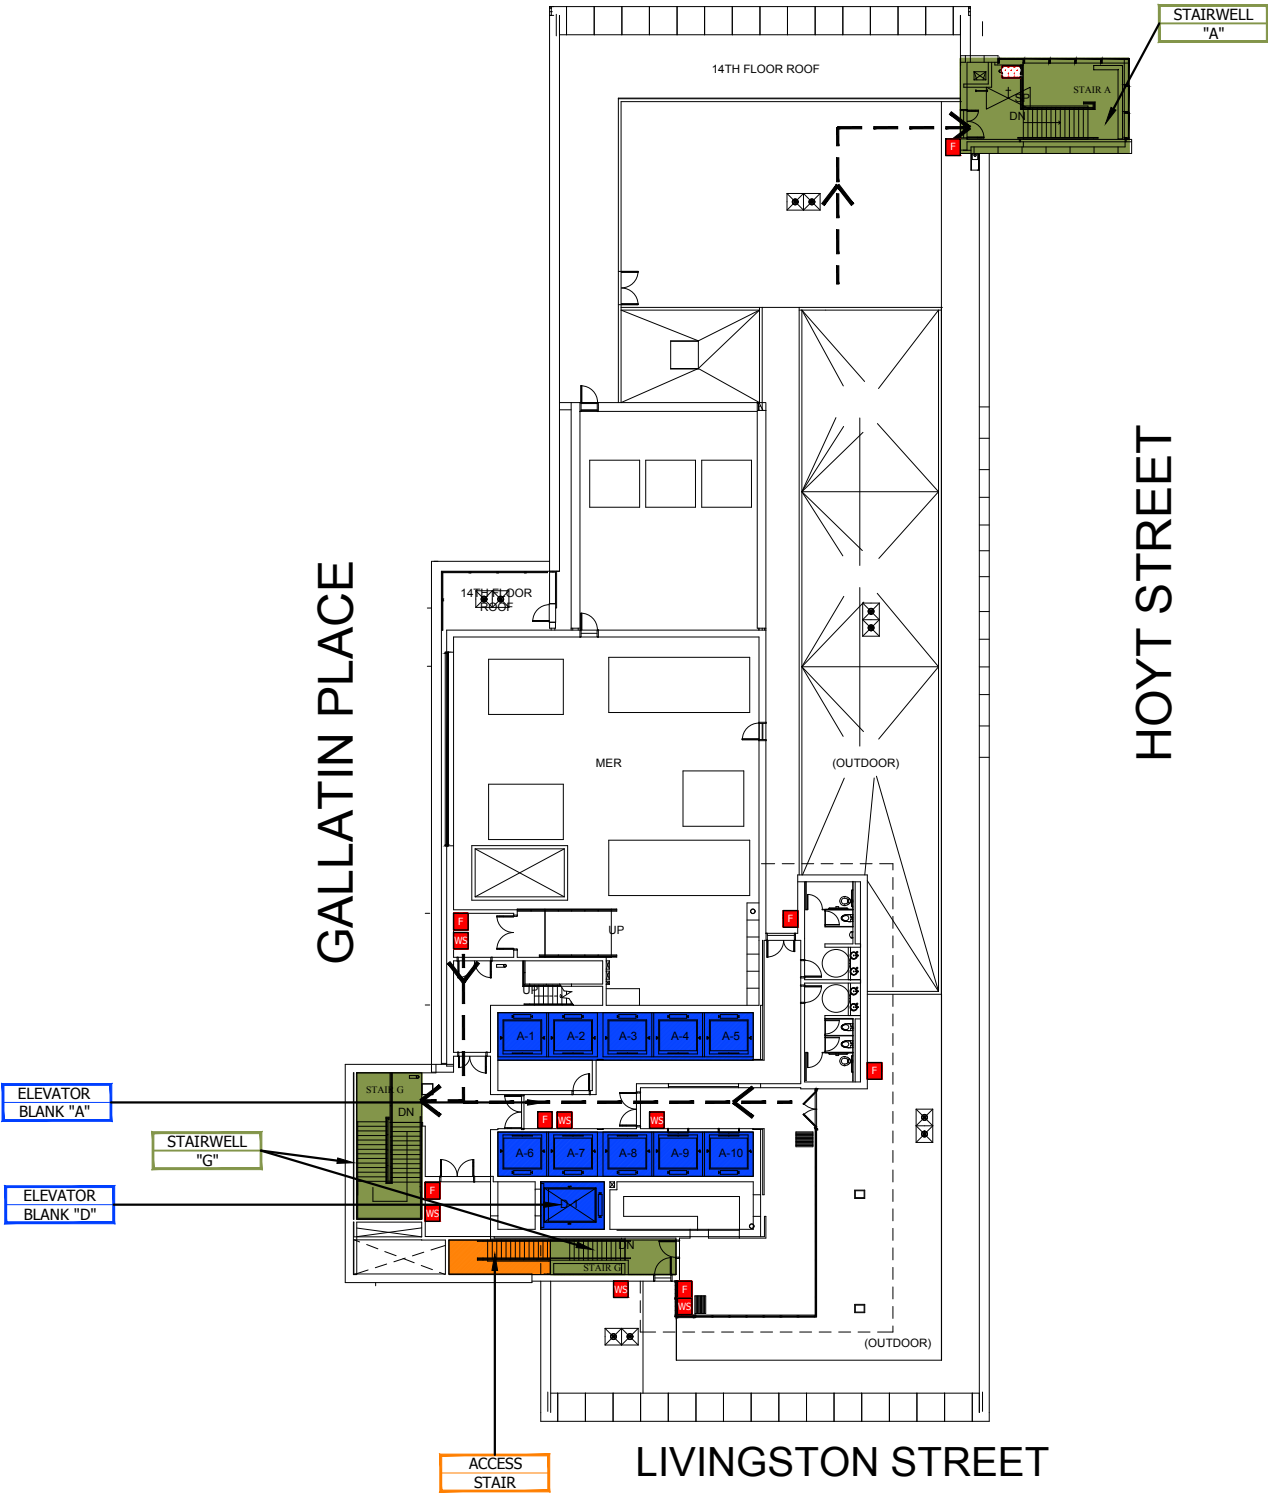

LEGEND:

PULL STATION	STANDPIPE/ SPRINKLER ISOLATION VALVE	FDNY CONNECTION COMBINATION	IN-BUILDING RELOCATION AREA	MECHANICAL/ELECTRICAL SPACES (MER)	
FIRE HOSE OUTLET	SPRINKLER FLOOR CONTROL VALVE	EVACUATION ROUTE	ELEVATOR CAR & NUMBER DESIGNATION	ELEVATOR BLIND SHAFT	
WARDEN STATION	SPRINKLER OS&Y SECTION VALVE	CONCRETE WALL	STAIRWELL	NO ACCESS STAIRWELL	
FIRE COMMAND STATION	STANDPIPE ISOLATION VALVE		CONVENIENCE/ ACCESS STAIRS		
FIRE PUMP/ JOCKEY PUMP	3 WAY MANIFOLD				

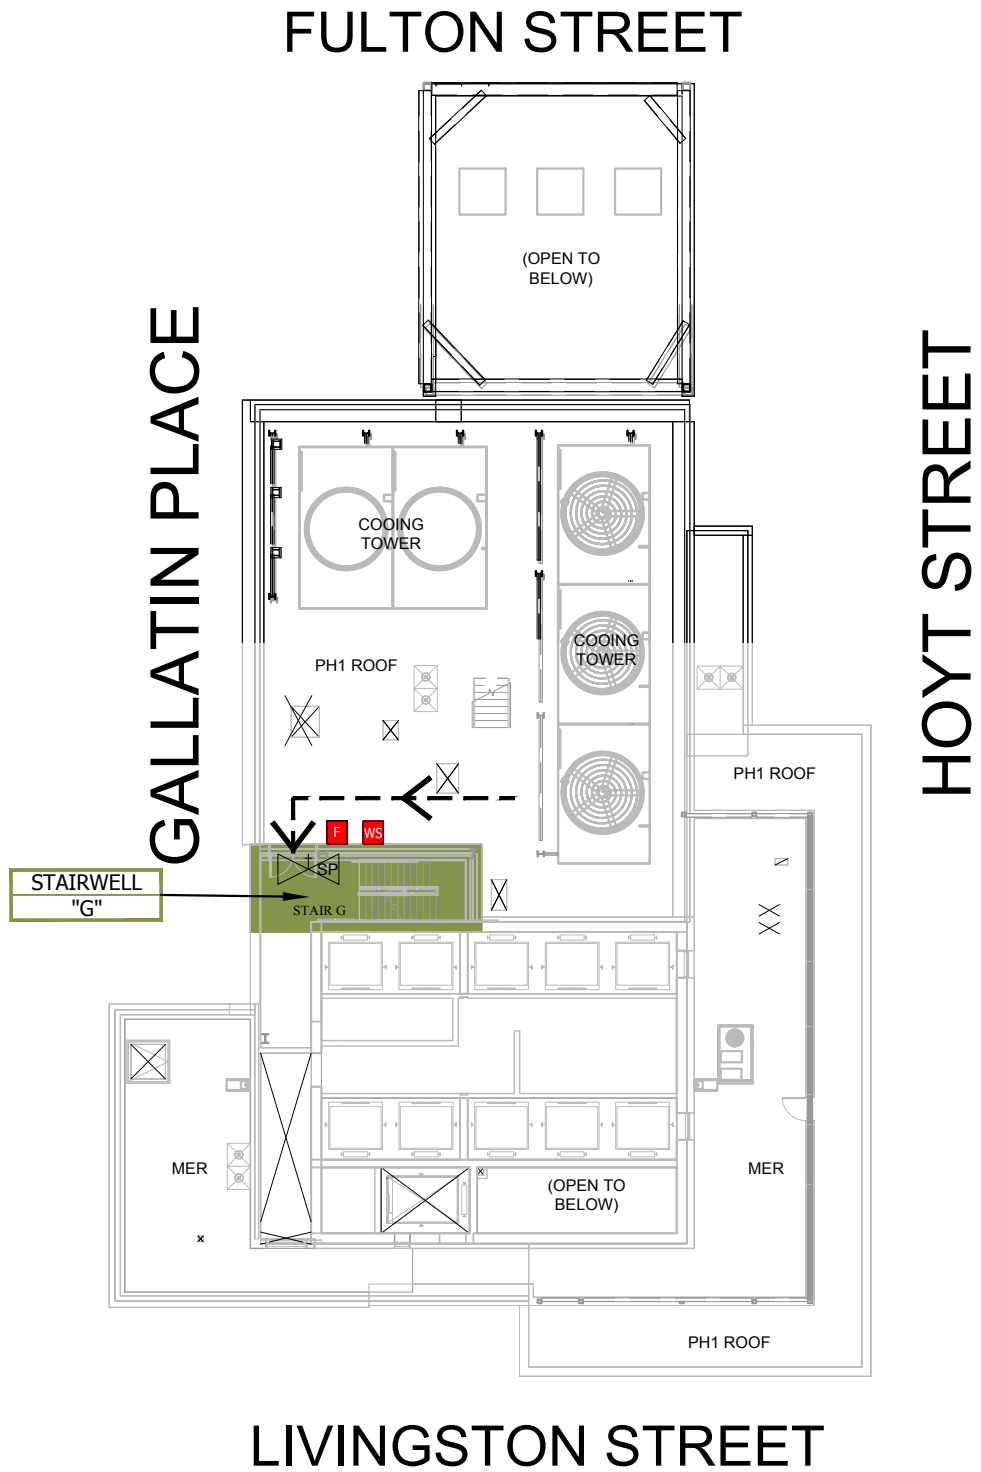

TOWER
CONSULTING ENGINEERS

120 West 31st Street - 7TH FLOOR
NEW YORK, N.Y. 10001
PHONE NO: (212) 444-8786
EMAIL: INFO@TOWERCE.COM
WWW.TOWERCE.COM

THESE DRAWINGS ARE THE PROPERTY OF TOWER CONSULTING ENGINEERS (TCE). THEY MAY NOT BE COPIED, REPRODUCED, ALTERED OR DISTRIBUTED WITHOUT WRITTEN CONSENT FROM TCE. THESE PLANS SHALL BE USED FOR ONLY THE WORK TYPE INDICATED ON THE DRAWINGS. LICENSED CONTRACTOR(S)/VENDOR(S) SHALL CONFIRM ALL FIELD CONDITIONS INCLUDING BUT NOT LIMITED TO LOCATION, DIMENSIONS, APPLICABLE CODES FROM ALL AUTHORITIES HAVING JURISDICTION (AHJ) AND LAWS ENACTED PRIOR TO INITIATING ANY WORK AND NOTIFY TCE OF ANY CONFLICTS, DISCREPANCIES, ERRORS, AND OMISSIONS WITNESSED IN WRITING. INSTALLATION OF ANY SCOPE INDICATED ON THE DRAWINGS SHALL NOT COMMENCE UNTIL THE AHJ APPROVES ANY AND ALL SCOPES SHOWN. THIS APPROVAL SHALL BE INDICATED ON THE PLANS VIA AN APPROVAL STAMP. TCE SHALL BE DEEMED AS THE AUTHOR OF THESE DRAWINGS AND SHALL RETAIN ALL STATUTORY, COMMON LAWS, EDUCATION LAWS, AND ANY OTHER RESERVED RIGHTS INCLUDING COPYRIGHT. THE OWNER OF THE PREMISES SHALL BE ALLOWED TO RETAIN COPIES OF THE DRAWINGS, SPECIFICATIONS, AND OTHER DOCUMENTS FOR THIS PROJECT ONLY FOR THE WORK INDICATED ON THE DRAWINGS.

SEAL & SIGNATURE

AHJ STAMP

PROJECT NAME AND ADDRESS :

422 FULTON STREET
BROOKLYN, NY 11216

TITLE :


PENTHOUSE 2

FDNY RECORD ID #:

2022-EPPGFS-XXXXXX-PLAN

DATE: 07/13/2022
TCE JOB NUMBER: TISHAYK02
DRAWING BY: RAH
CHECK BY: MMZ
TCE TEAM LEAD: GIK
PROJECT MANAGER: ATY
DRAWING NUMBER:

NORTH ARROW

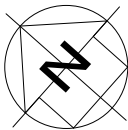

FL-17

SHEET:25OF 27

LEGEND:

PULL STATION	STANDPIPE/ SPRINKLER ISOLATION VALVE	FDNY CONNECTION COMBINATION	IN-BUILDING RELOCATION AREA	MECHANICAL/ELECTRICAL SPACES (MER)	
FIRE HOSE OUTLET	SPRINKLER FLOOR CONTROL VALVE	EVACUATION ROUTE	ELEVATOR CAR & NUMBER DESIGNATION	ELEVATOR BLIND SHAFT	
WARDEN STATION	SPRINKLER OS&Y SECTION VALVE	CONCRETE WALL	STAIRWELL	NO ACCESS STAIRWELL	
FIRE COMMAND STATION	STANDPIPE ISOLATION VALVE		CONVENIENCE/ ACCESS STAIRS		
FIRE PUMP/ JOCKEY PUMP	3 WAY MANIFOLD				


FULTON STREET

GALLATIN PLACE

HOYT STREET

LIVINGSTON STREET

STAIRWELL
"G"

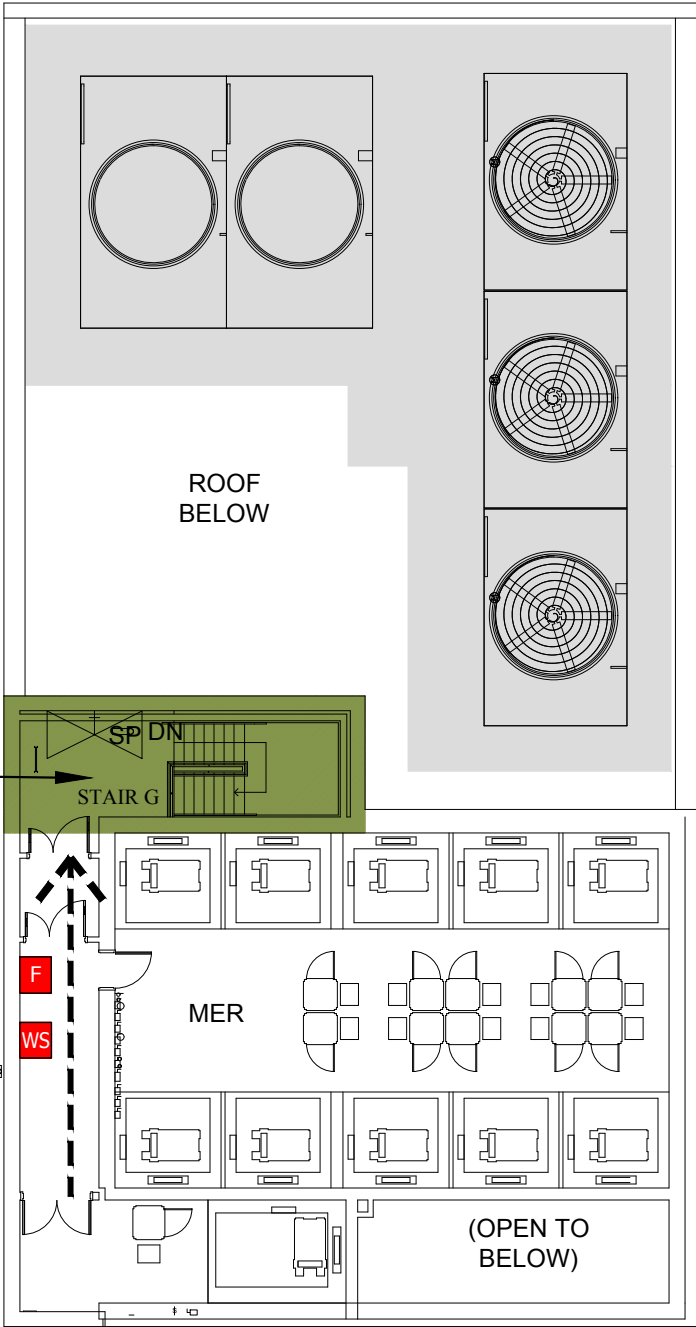

TOWER
CONSULTING ENGINEERS

120 West 31st Street - 7TH FLOOR
NEW YORK, N.Y. 10001
PHONE NO: (212) 444-8786
EMAIL: INFO@TOWERCE.COM
WWW.TOWERCE.COM

THESE DRAWINGS ARE THE PROPERTY OF TOWER CONSULTING ENGINEERS (TCE). THEY MAY NOT BE COPIED, REPRODUCED, ALTERED OR DISTRIBUTED WITHOUT WRITTEN CONSENT FROM TCE. THESE PLANS SHALL BE USED FOR ONLY THE WORK TYPE INDICATED ON THE DRAWINGS. LICENSED CONTRACTOR(S)/VENDOR(S) SHALL CONFIRM ALL FIELD CONDITIONS INCLUDING BUT NOT LIMITED TO LOCATION, DIMENSIONS, APPLICABLE CODES FROM ALL AUTHORITIES HAVING JURISDICTION (AHJ) AND LAWS ENACTED PRIOR TO INITIATING ANY WORK AND NOTIFY TCE OF ANY CONFLICTS, DISCREPANCIES, ERRORS, AND OMISSIONS WITNESSED IN WRITING. INSTALLATION OF ANY SCOPE INDICATED ON THE DRAWINGS SHALL NOT COMMENCE UNTIL THE AHJ APPROVES ANY AND ALL SCOPES SHOWN. THIS APPROVAL SHALL BE INDICATED ON THE PLANS VIA AN APPROVAL STAMP. TCE SHALL BE DEEMED AS THE AUTHOR OF THESE DRAWINGS AND SHALL RETAIN ALL STATUTORY, COMMON LAWS, EDUCATION LAWS, AND ANY OTHER RESERVED RIGHTS INCLUDING COPYRIGHT. THE OWNER OF THE PREMISES SHALL BE ALLOWED TO RETAIN COPIES OF THE DRAWINGS, SPECIFICATIONS, AND OTHER DOCUMENTS FOR THIS PROJECT ONLY FOR THE WORK INDICATED ON THE DRAWINGS.

SEAL & SIGNATURE

AHJ STAMP

PROJECT NAME AND ADDRESS :

422 FULTON STREET
BROOKLYN, NY 11216

TITLE :

PENTHOUSE 3

FDNY RECORD ID #:

2022-EPPGFS-XXXXXX-PLAN

DATE: 07/13/2022
TCE JOB NUMBER: TISHAYK02
DRAWING BY: RAH
CHECK BY: MMZ
TCE TEAM LEAD: GIK
PROJECT MANAGER: ATY
DRAWING NUMBER:



FL-18

SHEET:26OF 27

LEGEND:

PULL STATION	STANDPIPE/ SPRINKLER ISOLATION VALVE	FDNY CONNECTION COMBINATION	IN-BUILDING RELOCATION AREA	MECHANICAL/ELECTRICAL SPACES (MER)	
FIRE HOSE OUTLET	SPRINKLER FLOOR CONTROL VALVE	EVACUATION ROUTE	ELEVATOR CAR & NUMBER DESIGNATION	ELEVATOR BLIND SHAFT	
WARDEN STATION	SPRINKLER OS&Y SECTION VALVE	CONCRETE WALL	STAIRWELL	NO ACCESS STAIRWELL	
FIRE COMMAND STATION	STANDPIPE ISOLATION VALVE		CONVENIENCE/ ACCESS STAIRS		
FIRE PUMP/ JOCKEY PUMP	3 WAY MANIFOLD				



X	XX-XX-XXXX	XXXXXXXXXXXXXX
NO.	DATE	DETAILS

SEAL & SIGNATURE

LEGEND

- ## LEGEND:

- | | | | |
|---|--------------------------------------|---|---------------------------------------|
|  | IN-BUILDING
RELOCATION AREA |  | MECHANICAL/ELECTRICAL
SPACES (MER) |
|  | ELEVATOR CAR &
NUMBER DESIGNATION |  | ELEVATOR BLIND SHAFT |
|  | STAIRWELL |  | NO ACCESS STAIRWELL |
|  | CONVENIENCE/
ACCESS STAIRS | | |




TITLE :

FDNY RECORD ID #:

2022-EPPGFS-XXXXXX-PLAN

DATE:	07/13/2022
TCE JOB NUMBER:	TISHAYK0
DRAWING BY:	RAH
CHECK BY:	MM
TCE TEAM LEAD:	GIR
PROJECT MANAGER:	ATY
DRAWING NUMBER:	

NORTH ARROW

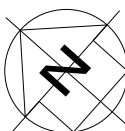

R-1

SHEET:27 OF 27

FIRE ALARM SYMBOL LIST

CONTROL UNITS (PANELS) SYMBOLS

	FIRE ALARM CONTROL PANEL
	FIRE ALARM DATA GATHERING PANEL
	FIRE ALARM TRANSDUCER # = TRANSDUCER NUMBER
	FIRE ALARM ANNUNCIATOR
	NOTIFICATION CIRCUIT POWER BOOSTER PANEL
	FIRE ALARM TERMINAL CABINET
	BATTERY CABINET
	VOICE EVACUATION CONTROL UNIT
	REMOTE VOICE EVACUATION MICROPHONE
	GRAPHIC ANNUNCIATOR PANEL
	UNINTERRUPTIBLE POWER SUPPLY
	CRT
	PRINTER
	EMERGENCY COMMUNICATIONS CONTROL UNIT
	FIRE SUPPRESSION CONTROL PANEL, 'XX' DENOTES SUPPRESSION TYPE: PA = PRE-EXTINGUISH HL = HALON CA = CLEAN AGENT GAS
	FIRE SUPPRESSION CONTROL UNIT, 'XX' DENOTES SUPPRESSION TYPE: PA = PRE-EXTINGUISH HL = HALON CA = CLEAN AGENT GAS
	REMOTE TRANSDUCER PANEL
	AUTONOMOUS CONTROL UNIT
	ELEVATOR STATUS/RECALL
	DIGITAL ALARM COMMUNICATION TRANSMITTER
	POST-FIRE SMOKE PURGE PANEL
	SPRINKLER ALARM PANEL
	FIREFIGHTER'S SMOKE CONTROL PANEL

NOTIFICATION APPLIANCES SYMBOLS

	NOTIFICATION APPLIANCE SUBSCRIPTS (XX) W = WEATHERPROOF WG = WIND GUARD H = HIGH ALARABLE SETTING L = LOW ALARABLE SETTING C = CEILING MOUNT WM = MOUNTING SETTING (W = SPEAKER TAP) P = PENDENT SL = SMOKE LIGHT R = REMOTE INDICATOR
	HORN ONLY C = CEILING MOUNT
	SPEAKER ONLY C = CEILING MOUNT
	BELL - SINGLE STROKE
	BELL - TROUBLE
	GONG
	VISIBLE ONLY (STROBE) - WALL MOUNT CD = CANDELA RATING/SETTING
	VISIBLE ONLY (STROBE) - CEILING MOUNT CD = CANDELA RATING/SETTING
	COMBINATION HORN/VISIBLE CD = CANDELA RATING/SETTING C = CEILING MOUNT
	COMBINATION SPEAKER/VISIBLE CD = CANDELA RATING/SETTING C = CEILING MOUNT
	REMOTE INDICATOR - WALL MOUNT
	REMOTE ALARM INDICATING AND TEST SWITCH
	REMOTE INDICATOR - CEILING MOUNT

RELATED EQUIPMENT


	DOOR HOLDER
	DOOR CLOSER
	INTEGRATED SMOKE SENSOR AND DOOR CLOSER
	END OF LINE RESISTOR
	FIRE SERVICE OR EMERGENCY PHONE STATION STATION 'X' DENOTES TYPE: J = JACK H = HANDSET A = ACCESSIBLE
	ISOLATOR MODULE (STYLE 6 OR 7 FAULT PROTECTION)
	JUNCTION BOX
	AIR SAMPLING DETECTOR PIPING (E.G. VESPA)
	CARD READER

BASE BUILDING FIRE ALARM SYSTEM FILED UNDER DOB APPLICATION#: 121275574

Tower
Consulting
Engineers
Review
Comments:
07/18/2022

SIGNAL INITIATING DEVICES & ACTIVATION SWITCHES SYMBOLS

	MANUAL STATION - FULL STATION/FIRE ALARM BOX 'X' DENOTES TYPE: CD = CARBON MONOXIDE DC = DRY CHEMICAL HL = HALON F = FIRE ALARM FO = FOAM WC = WET CHEMICAL CA = CLEAN AGENT WM = WATER MIST DL = DELUUSE FIRE SPRINKLER PRE = PRE-EXTINGUISH
	ABORT SWITCH, 'XX' DENOTES TYPE: CD = CARBON MONOXIDE DC = DRY CHEMICAL HL = HALON F = FIRE ALARM FO = FOAM WC = WET CHEMICAL CA = CLEAN AGENT WM = WATER MIST DL = DELUUSE FIRE SPRINKLER PRE = PRE-EXTINGUISH
	HEAT DETECTOR/SENSOR (THERMAL DETECTION) ORIENTATION NOT TO BE CHANGED
	HEAT DETECTOR/SENSOR, 'XX' DENOTES TYPE: RF = COMBINATION RATE OF RISE/PERCENT TEMPERATURE WC = WET CHEMICAL F = FIRED TEMPERATURE R = RATE OF RISE ONLY
	HEAT DETECTOR - LINE TYPE
	SMOKE DETECTOR/SENSOR, 'XX' DENOTES TYPE: AS = AIR SAMPLING P = PHOTOELECTRIC R = RELAY BASE SS = SINGLE STATION SS = SOUNDER BASE ID = IDU/CT
	SMOKE/HEAT DETECTOR/SENSOR COMBINATION
	SMOKE DETECTOR/SENSOR - BEAM TRANSMITTER
	SMOKE DETECTOR/SENSOR - BEAM RECEIVER
	SMOKE DETECTOR/SENSOR FOR DUCT
	GAS DETECTOR/SENSOR, 'XX' DENOTES TYPE: CD = CARBON MONOXIDE DC = DRY CHEMICAL HL = HYDROGEN CHLORIDE CH = METHANE
	FLAME DETECTOR, 'XX' DENOTES TYPE: UL = ULTRAVIOLET IR = INFRARED ULW = COMBINATION ULTRAVIOLET/INFRARED VR = VISIBLE RADIATION
	FLOW DETECTOR SWITCH
	PRESSURE DETECTOR SWITCH
	VALVE SUPERVISORY SWITCH
	LEVEL DETECTOR SWITCH, 'XX' DENOTES TYPE: H = HIGH LO = LOW
	HIGH TEMPERATURE SWITCH
	LOW TEMPERATURE SWITCH
	ADDRESSABLE INPUT MODULE
	ADDRESSABLE OUTPUT MODULE
	ADDRESSABLE INPUT/OUTPUT MODULE # DENOTES NUMBER OF INPUTS AND OUTPUTS
	NON-ADDRESSABLE OUTPUT RELAY

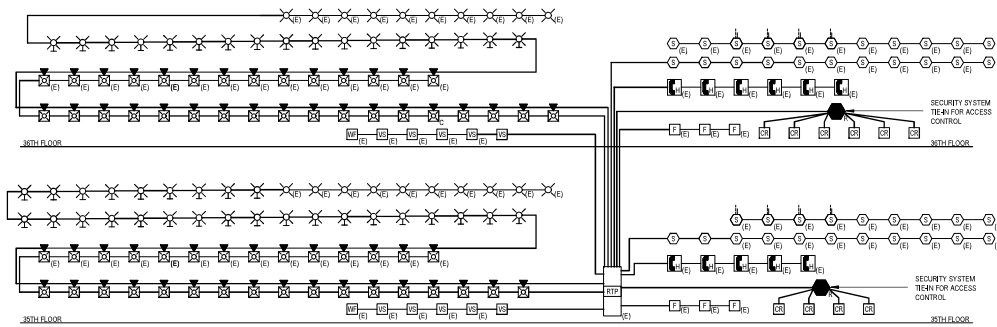

PARTIAL FIRE ALARM RISER
SCALE: NONE


Reflect Strobe Booster Panels that Siemens will be proposing on Riser Diagram and locations.

FIRE ALARM RISER DIAGRAM NOTES:

- THIS IS NOT A POINT-TO-POINT WIRING DIAGRAM. USE THE DIAGRAM FOR ESTIMATING PURPOSES ONLY PRIOR TO STARTING ANY WORK. A WIRING POINT-TO-POINT WIRING DIAGRAM SHALL BE OBTAINED FROM BUILDING FIRE ALARM MAINTENANCE CONTRACTOR.
- MODIFY EXISTING Riser PANEL TO ACCOMMODATE NEW FIRE ALARM DEVICES. CONTRACTOR SHALL COORDINATE WITH BUILDING FIRE ALARM MAINTENANCE CONTRACTOR TO VERIFY CUP CAPACITY PRIOR TO FIELD.
- CONNECT ALL STROBE AND COMBINATION SPEAKERS/STROBE LIGHT UNITS TO TWO ALTERNATE ZONES AND SHALL BE SYNCHRONIZED. COORDINATE WITH ARCHITECT FOR EXACT MOUNTING LOCATIONS.
- SEE FIRE ALARM Riser PLAN FOR EXACT QUANTITY OF FIRE ALARM DEVICES. WHERE DISCREPANCIES ARE INDICATED FOR QUANTITIES ASSUME THE GREATEST QUANTITY DOCUMENTED.
- LOCATION OF FIRE ALARM DEVICES SHALL BE APPROVED BY ARCHITECT PRIOR TO INSTALLATION.
- CONTRACTOR SHALL COORDINATE OPERATION OF FIRE ALARM SYSTEM WITH BASE BUILDING FIRE ALARM MANUFACTURER.
- ALL FIRE ALARM TEST SHALL BE DONE BY BUILDING FIRE ALARM MAINTENANCE CONTRACTOR.
- THE FIRE ALARM SYSTEM MUST BE KEPT OPERATIONAL THROUGHOUT THE DURATION OF THE WORK. SMOKE DETECTORS MUST BE PROTECTED BY THE WORK. HALL CAUSE OUTLET AND DETECT AND THE DEVICE MUST BE PUT BACK ON LINE AT THE END OF EVERY DAY. IF THE SYSTEM TAKES OFF LINE FOR MORE THAN THE DAY, THEN A PRE-EXTINGUISH IS REQUIRED TO BE PROVIDED BY THE TOWN.
- PROVIDE REMOTE LED INDICATORS FOR ALL NEW AND EXISTING DUCT DETECTORS.
- THESE PLANS ARE IN FULL COMPLIANCE WITH ALL APPLICABLE NYC CODE REQUIREMENTS.
- ELECTRICAL CONTRACTOR SHALL USE EXISTING INFRASTRUCTURE. SHARED CAPACITY FOR FEEDING NEW FIRE ALARM DEVICES/EQUIPMENT.
- ELECTRICAL CONTRACTOR SHALL INCLUDE ALL PRE-EXTINGUISH IN HIS SCOPE OF WORK, (AND ALL).
- BASE BUILDING FIRE ALARM MAINTENANCE CONTRACTOR SHALL BE ADVISED.

FIRE ALARM SYSTEM OPERATION MATRIX (EMERGENCY VOICE/ALARM COMMUNICATION SYSTEM)

SYSTEM INPUTS		SYSTEM OUTPUTS		FIRE ALARM SYSTEM OPERATION MATRIX (EMERGENCY VOICE/ALARM COMMUNICATION SYSTEM)																																			
				CONTROL UNIT ANNUNCIATION													NOTIFICATION													OUTPUT DESCRIPTION									
				CONTROL UNIT ANNUNCIATION													NOTIFICATION													REQUIRED FIRE SAFETY CONTROL									
ACTIVITY LABEL AND INPUT IDENTIFICATION		CONTROL UNIT ANNUNCIATION													NOTIFICATION													REQUIRED FIRE SAFETY CONTROL											
ACTIVITY LABEL AND INPUT IDENTIFICATION		CONTROL UNIT ANNUNCIATION													NOTIFICATION													REQUIRED FIRE SAFETY CONTROL											
ACTIVITY LABEL AND INPUT IDENTIFICATION																																							

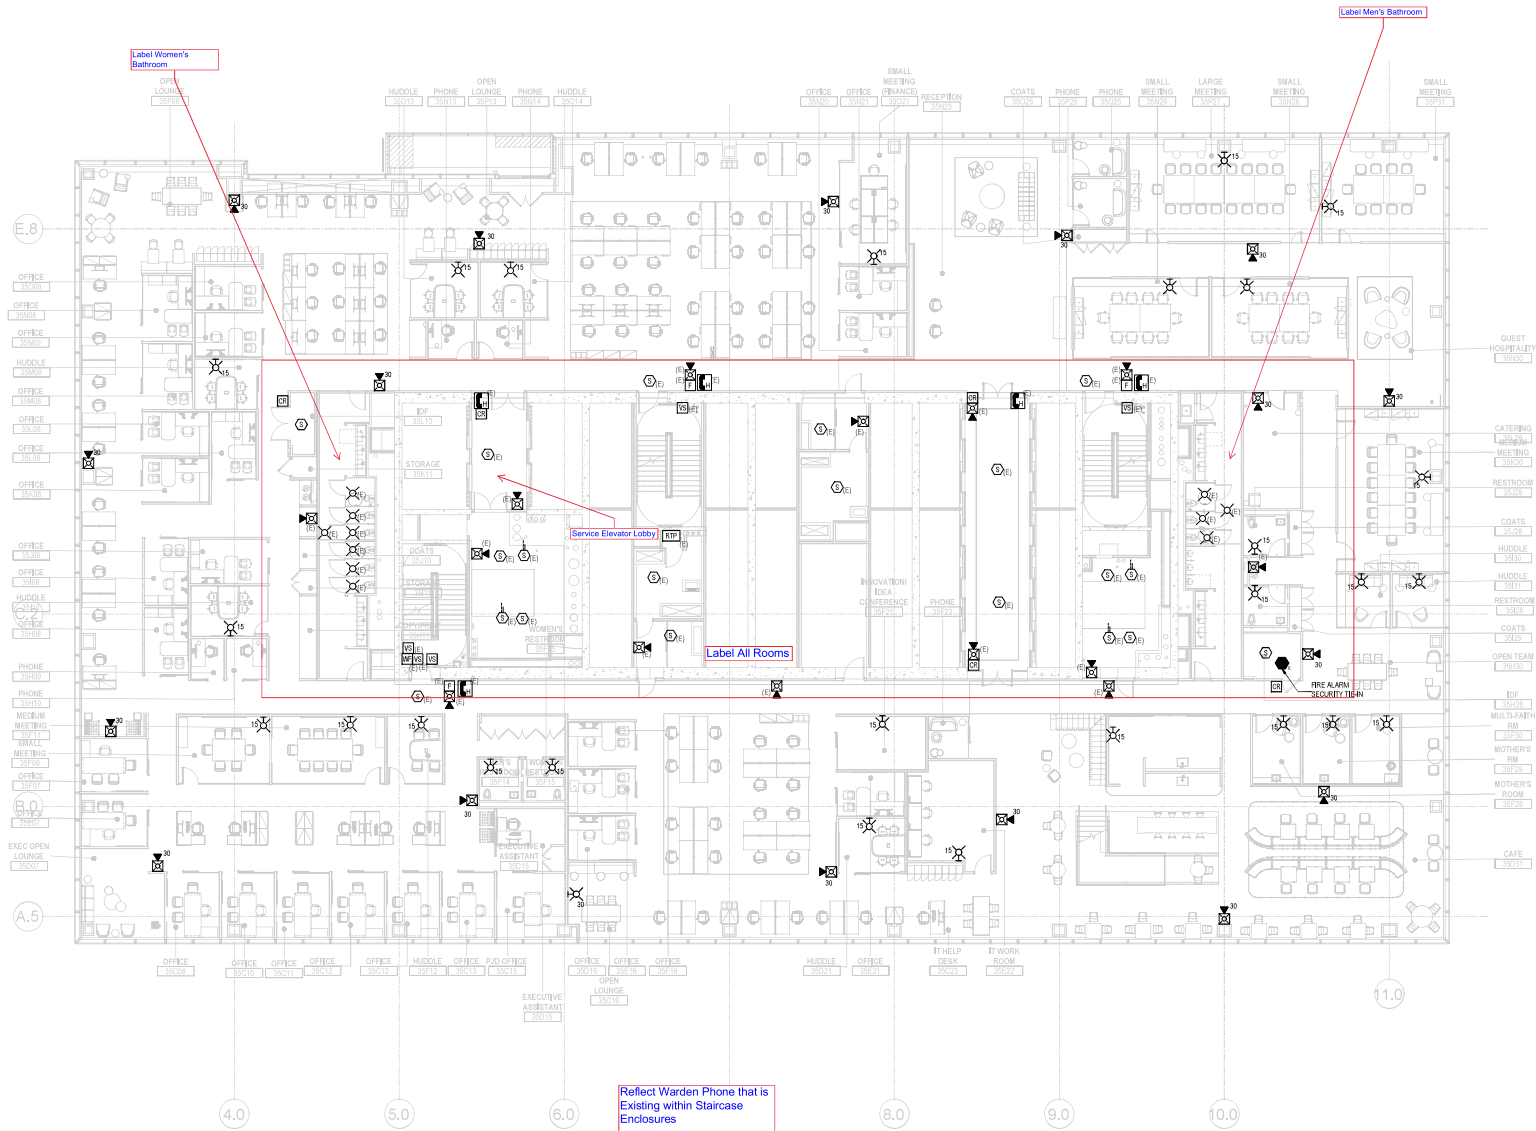

Date	Description
02/08/22	ISSUED FOR DD PROGRESS #2
03/23/22	ISSUED FOR DD PROGRESS #3
03/15/22	ISSUED FOR 100% DD
04/04/22	ISSUED FOR PLUMB
04/26/22	ISSUED FOR ESD
06/10/22	ISSUE FOR CONSTRUCTION

Seal / Signature

Project Name
TURNER CONSTRUCTION

Project Number
21016-01

Description
FIRE ALARM 35TH FLOOR PLAN

Scale
3/32" = 1'-0"

FA-100.00

008 NOV 4/20

04/08/2022_2 of 3


Gensler

1700 Broadway
Suite 400
New York, NY 10019
United States

STUDIO 301 ARCHITECTURE
ARCHITECT
BROOKLYN, NY 11225
Tel 718.714.8849

LEGACY ENGINEERS
MEP ENGINEER
1001 AVENUE OF THE
AMERICAS, 30TH FLOOR
NEW YORK, NY 10018
Tel 347.566.3128

LUMEN ARCHITECTURE
LIGHTING DESIGNER
108 EAST 16TH ST, #502
Tel 212.254.6469

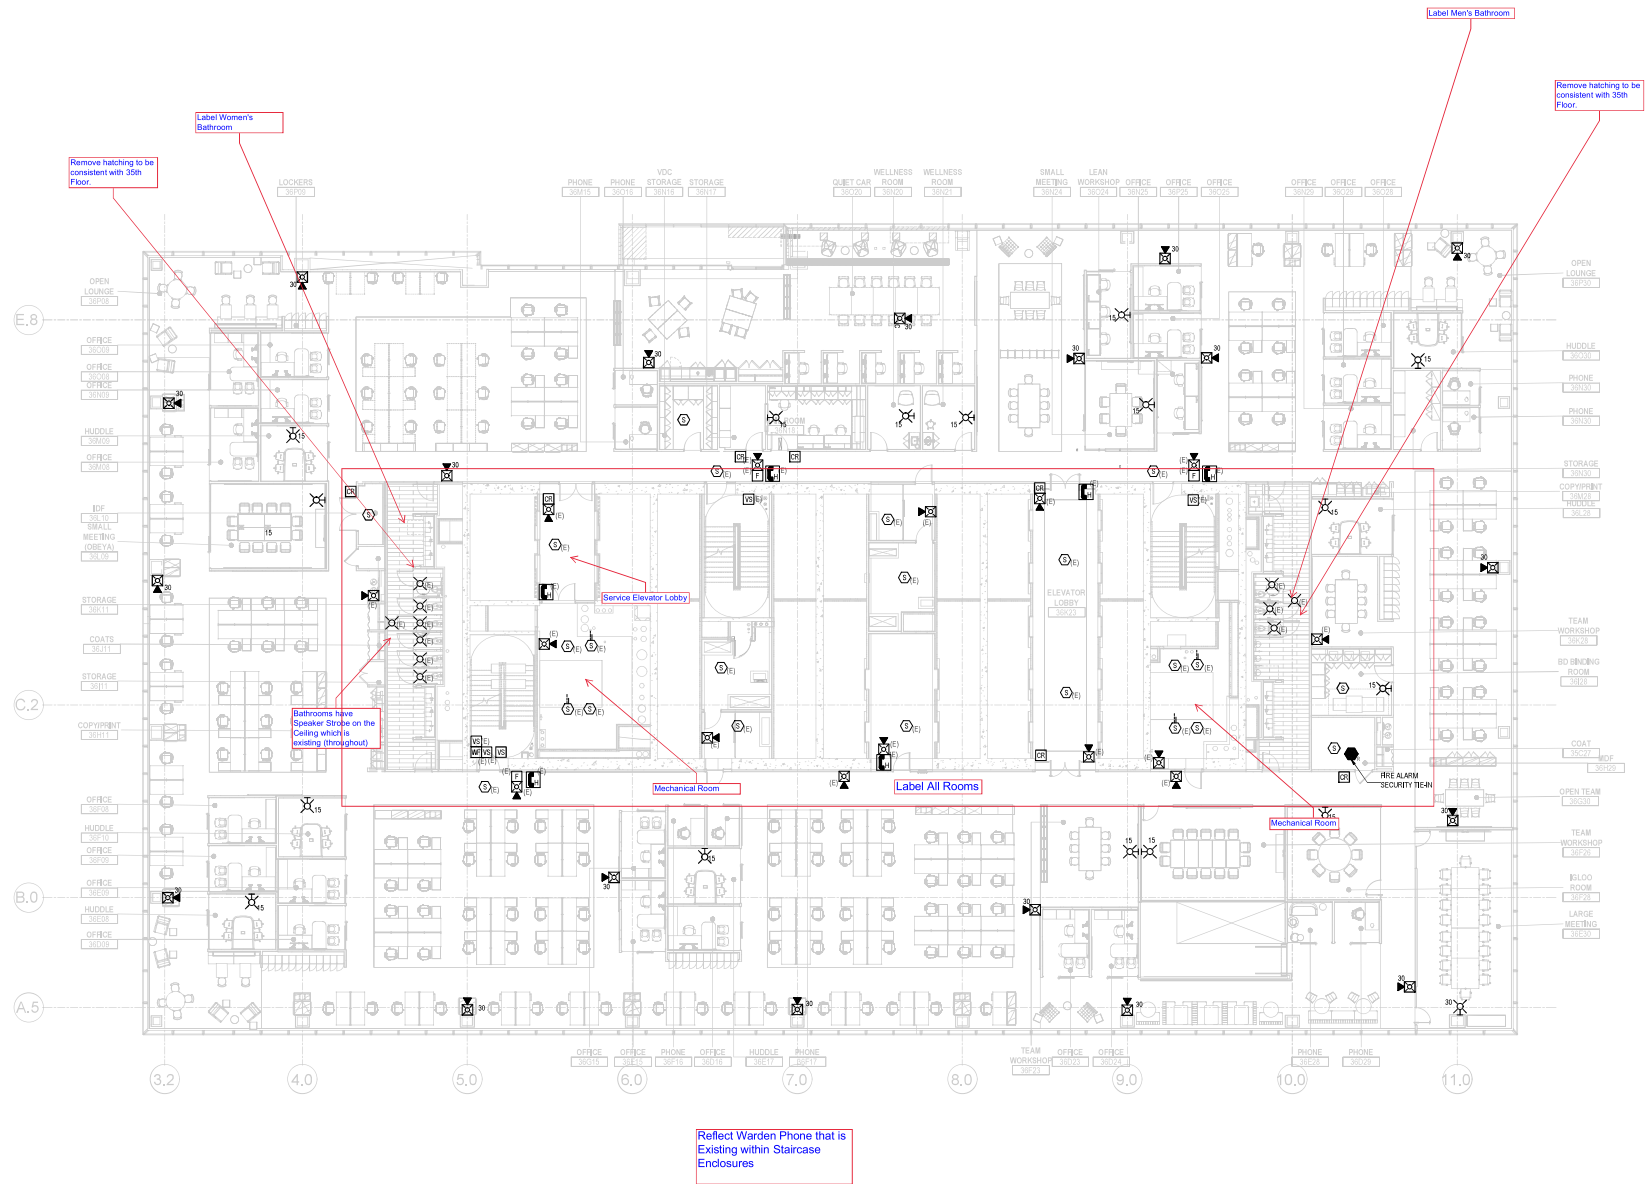

Date	Description
02/08/22	ISSUED FOR DD PROGRESS #2
02/23/22	ISSUED FOR DD PROGRESS #3
03/15/22	ISSUED FOR 100% DD
04/04/22	ISSUED FOR PLING
04/26/22	ISSUED FOR ESD
06/10/22	ISSUE FOR CONSTRUCTION

Seal / Signature

Project Name
TURNER CONSTRUCTION

Project Number
21016-01

Description
FIRE ALARM 36TH FLOOR PLAN

Scale
3/32" = 1'-0"

FA-101.00

008 NOV 2024

04/08/2024_3 of 3